





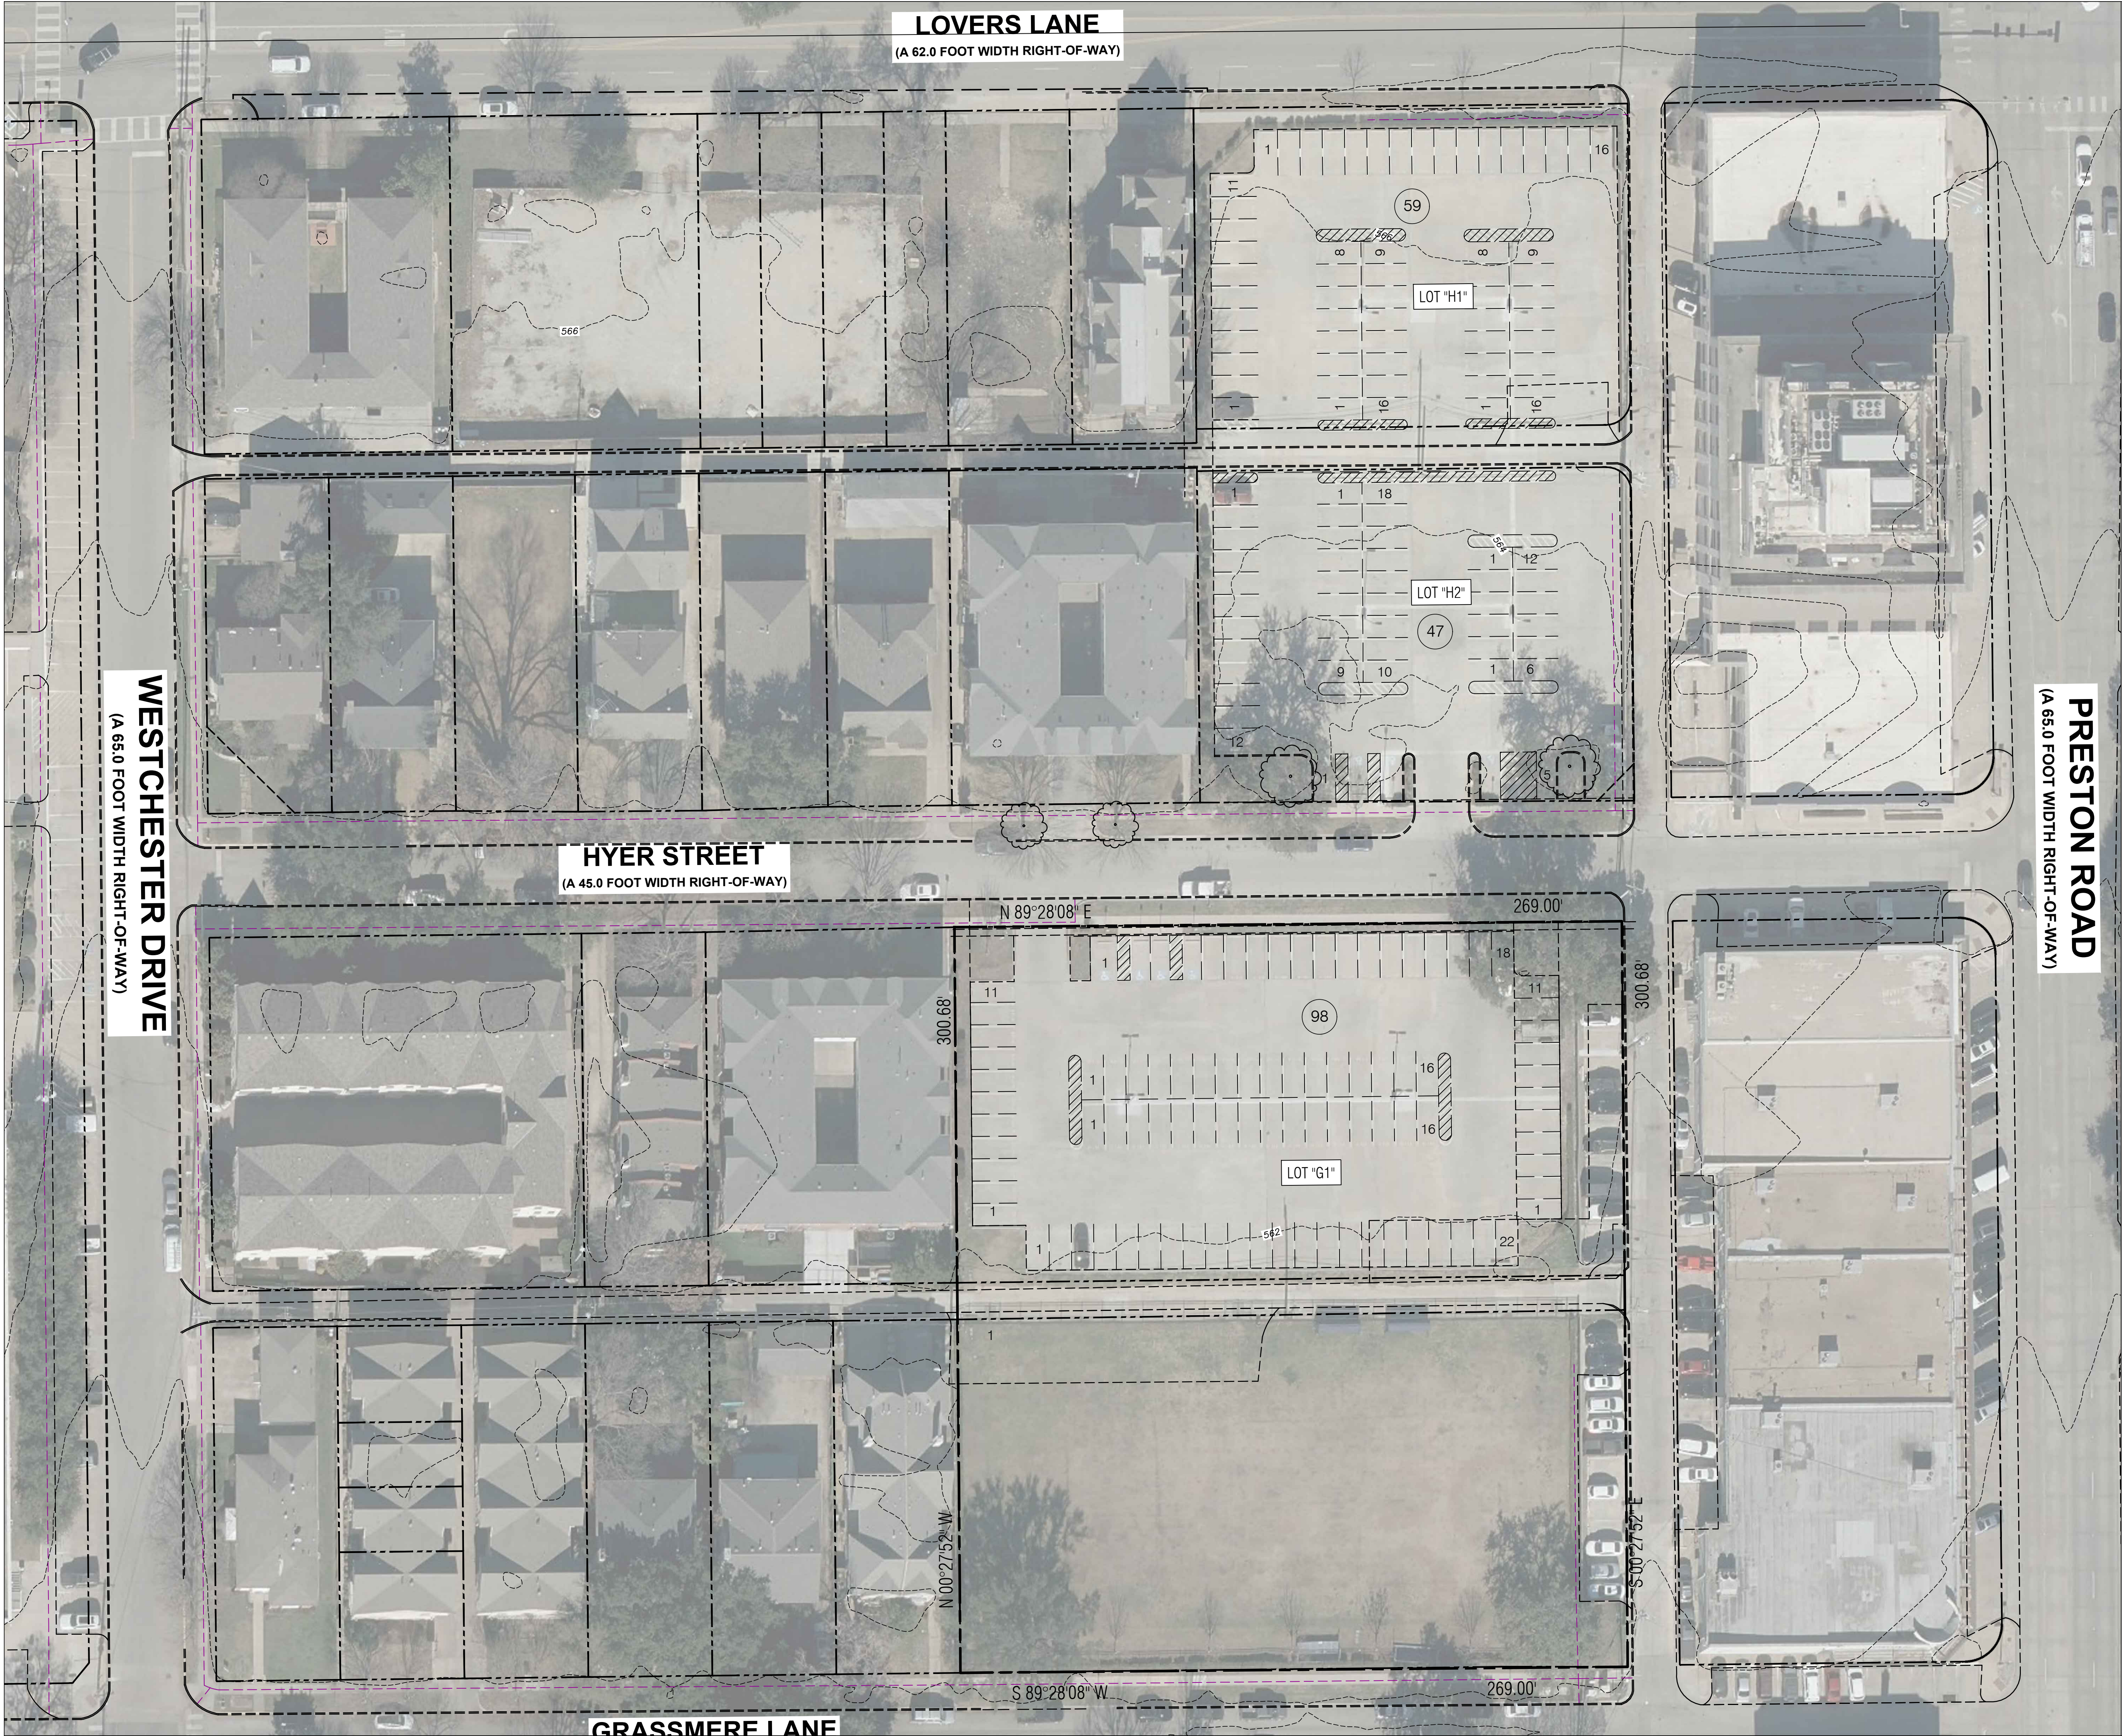

0 50 100 200
Scale: 1"=100'

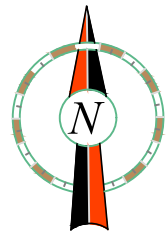

VLK|ARCHITECTS

ARCHITECT

VLK Architects, Inc.
5801 Tennyson Pkwy., Suite 100
Plano, Texas 75024
Main Phone: 972.265.1885
www.vlkarchitects.com

CIVIL ENGINEER

Glenn Engineering
TBPE Firm F-303
HUB #1752575193300
4500 Fuller Drive, Suite 220
Irving, Texas 75038
Main Phone: 972.717.5151
www.glennengineering.com

HIGHLAND PARK HIGH SCHOOL CAMPUS

THIS DOCUMENT IS RELEASED
FOR THE PURPOSE OF INTERIM
REVIEW UNDER THE AUTHORITY
OF MIKE GLENN, P.E. 35059,
ON March 3, 2026
IT IS NOT TO BE USED FOR
CONSTRUCTION PURPOSES

REVISIONS

Revision No.

Director	CMA
Approver	CMA
Designer	GEC
Proj. Arch.	GEC
Checker	RMR

PROJECT NO.

SHEET TITLE

OVERALL
SITE PLAN

SHEET NO.

C03.00




COPYRIGHT © 2023 VLK ARCHITECTS

HIGHLAND PARK HIGH SCHOOL

HIGHLAND PARK I.S.D.
CITY OF UNIVERSITY PARK, TX

NOTE: THE CITY OF UNIVERSITY PARK CONSTRUCTION STANDARDS APPLY, WHETHER INDICATED ON THESE PLANS OR NOT.

NOTE: EROSION CONTROL SHALL BE IN PLACE PRIOR TO THE DISTURBANCE OF ANY EXISTING SURFACE.

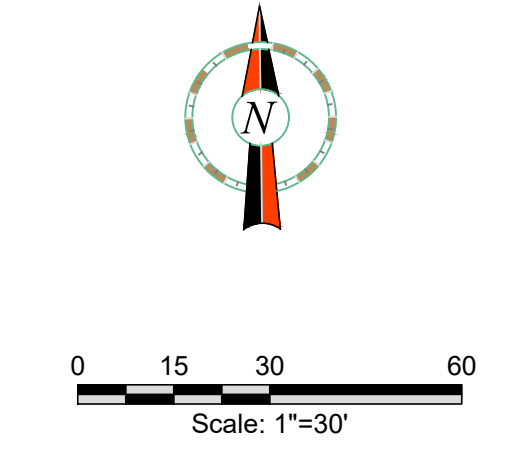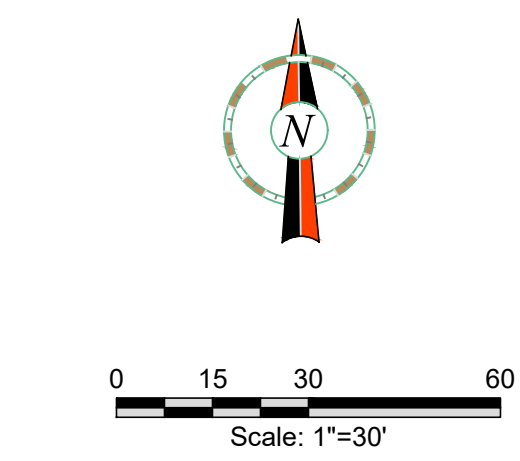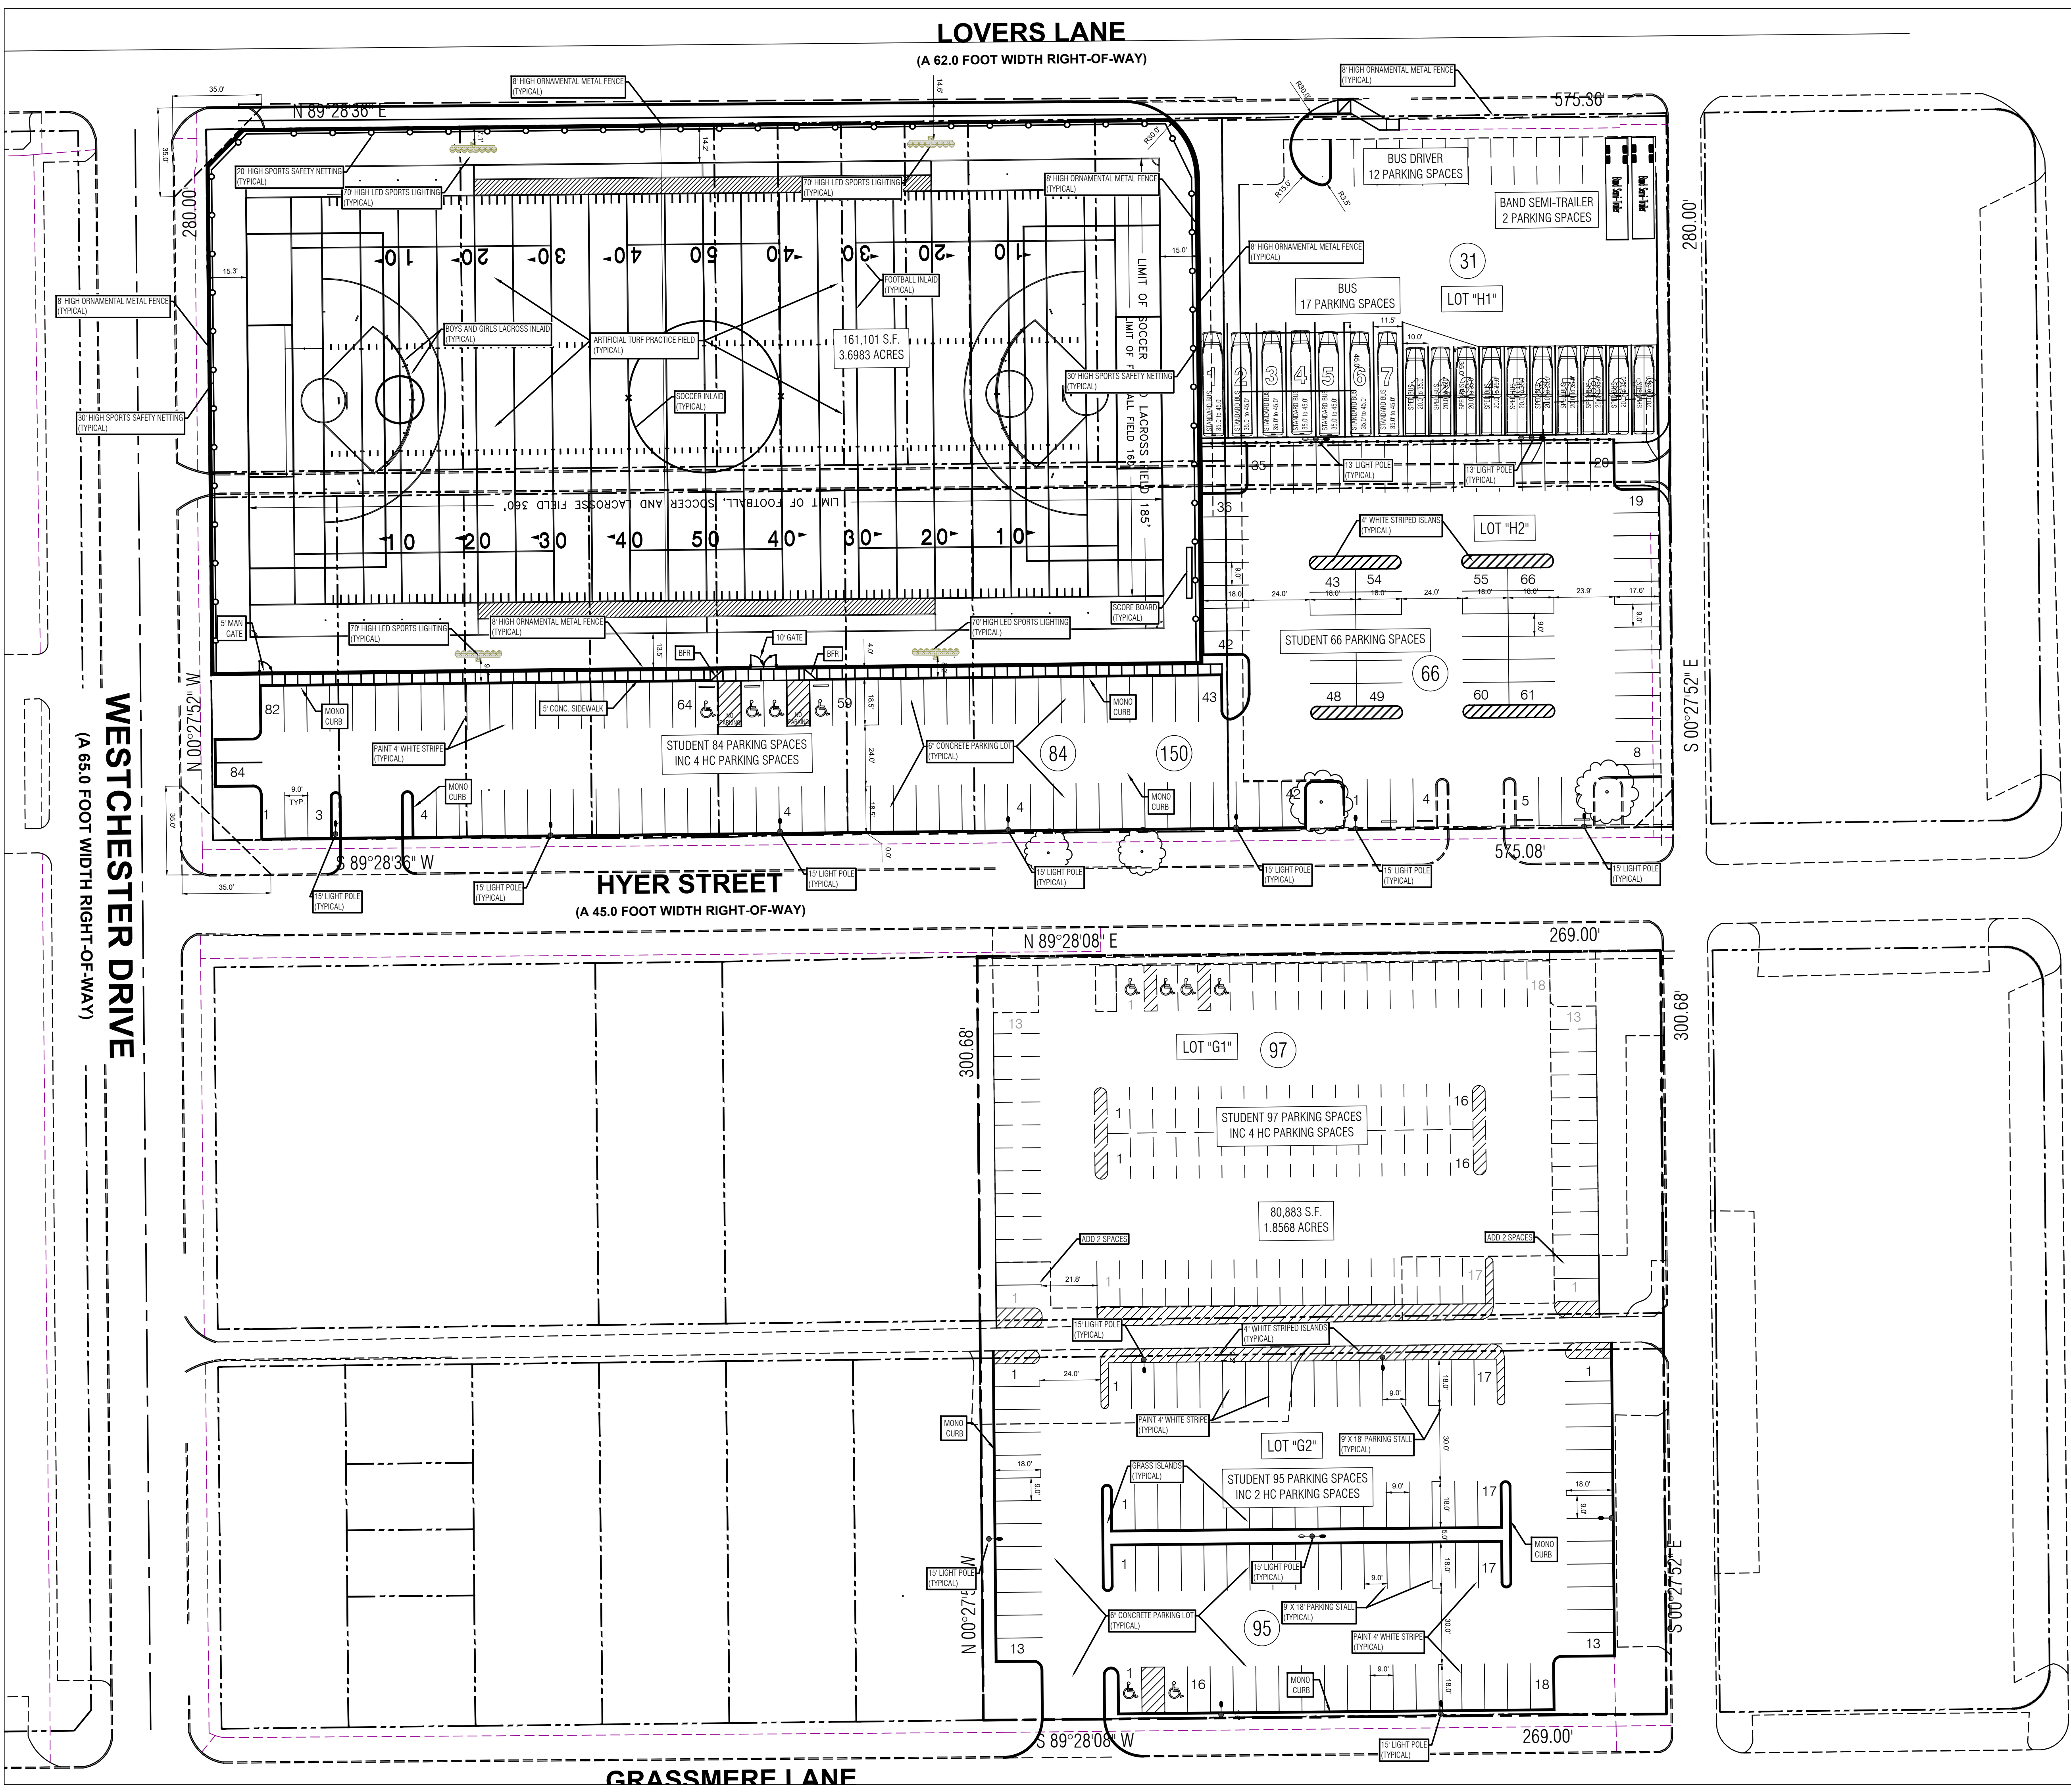

EXISTING STUDENT PARKING (INCLUDING HANDICAP SPACES)	
LOT "H1"	59 SPACES
LOT "H2"	47 SPACES
LOT "G1"	98 SPACES
TOTAL PARKING IN 3 LOTS	204 SPACES

PROPOSED STUDENT PARKING (INCLUDING HANDICAP SPACES)	
LOT "H1" TO BUS LOT	-59 SPACES
LOT "H2" RECONFIGURATION	150 SPACES
LOT "G1" RECONFIGURATION	97 SPACES
LOT "G2"(NEW GRASSMERE LOT)	95 SPACES
TOTAL PARKING	342 SPACES
NET INCREASE	283 SPACES



ARCHITECT

VLK Architects, Inc.
5801 Tennyson Pkwy., Suite 100
Plano, Texas 75024
Main Phone: 972.265.1885
www.vlkarchitects.com

CIVIL ENGINEER

Glenn Engineering
TBPE Firm F-303
HUB #1752575163300
4500 Fuller Drive, Suite 220
Irving, Texas 75038
Main Phone: 972.717.5151
www.glennengineering.com

HIGHLAND PARK HIGH SCHOOL CAMPUS

THIS DOCUMENT IS RELEASED
FOR THE PURPOSE OF INTERIM
REVIEW UNDER THE AUTHORITY
OF MIKE GLENN, P.E. 35059,
ON February 6, 2026
IT IS NOT TO BE USED FOR
CONSTRUCTION PURPOSES

REVISIONS	
Revision No.	

Director	CMA
Approver	CMA
Designer	GEC
Proj. Arch.	GEC
Checker	RMR

PROJECT NO.	




SHEET TITLE	
DETAILED SITE PLAN	

SHEET NO.	
C03.01	

COPYRIGHT © 2023 VLK ARCHITECTS

HIGHLAND PARK HIGH SCHOOL

CITY OF UNIVERSITY PARK, TX

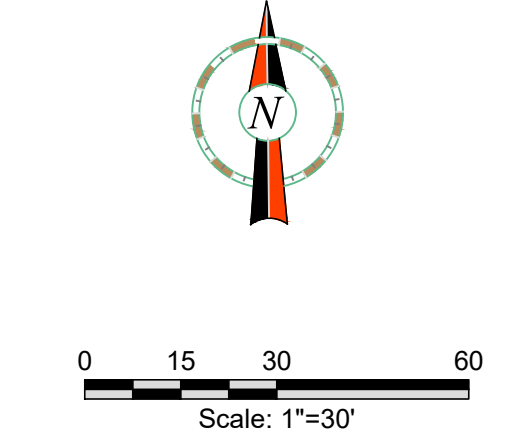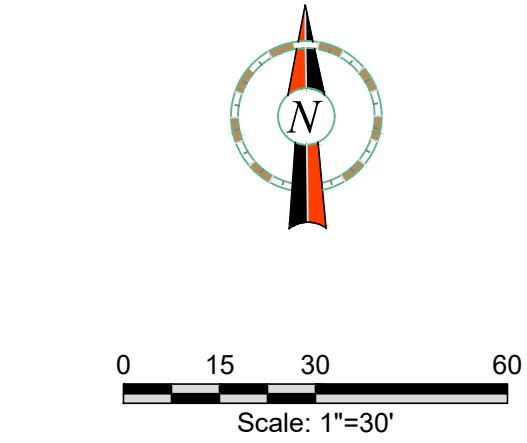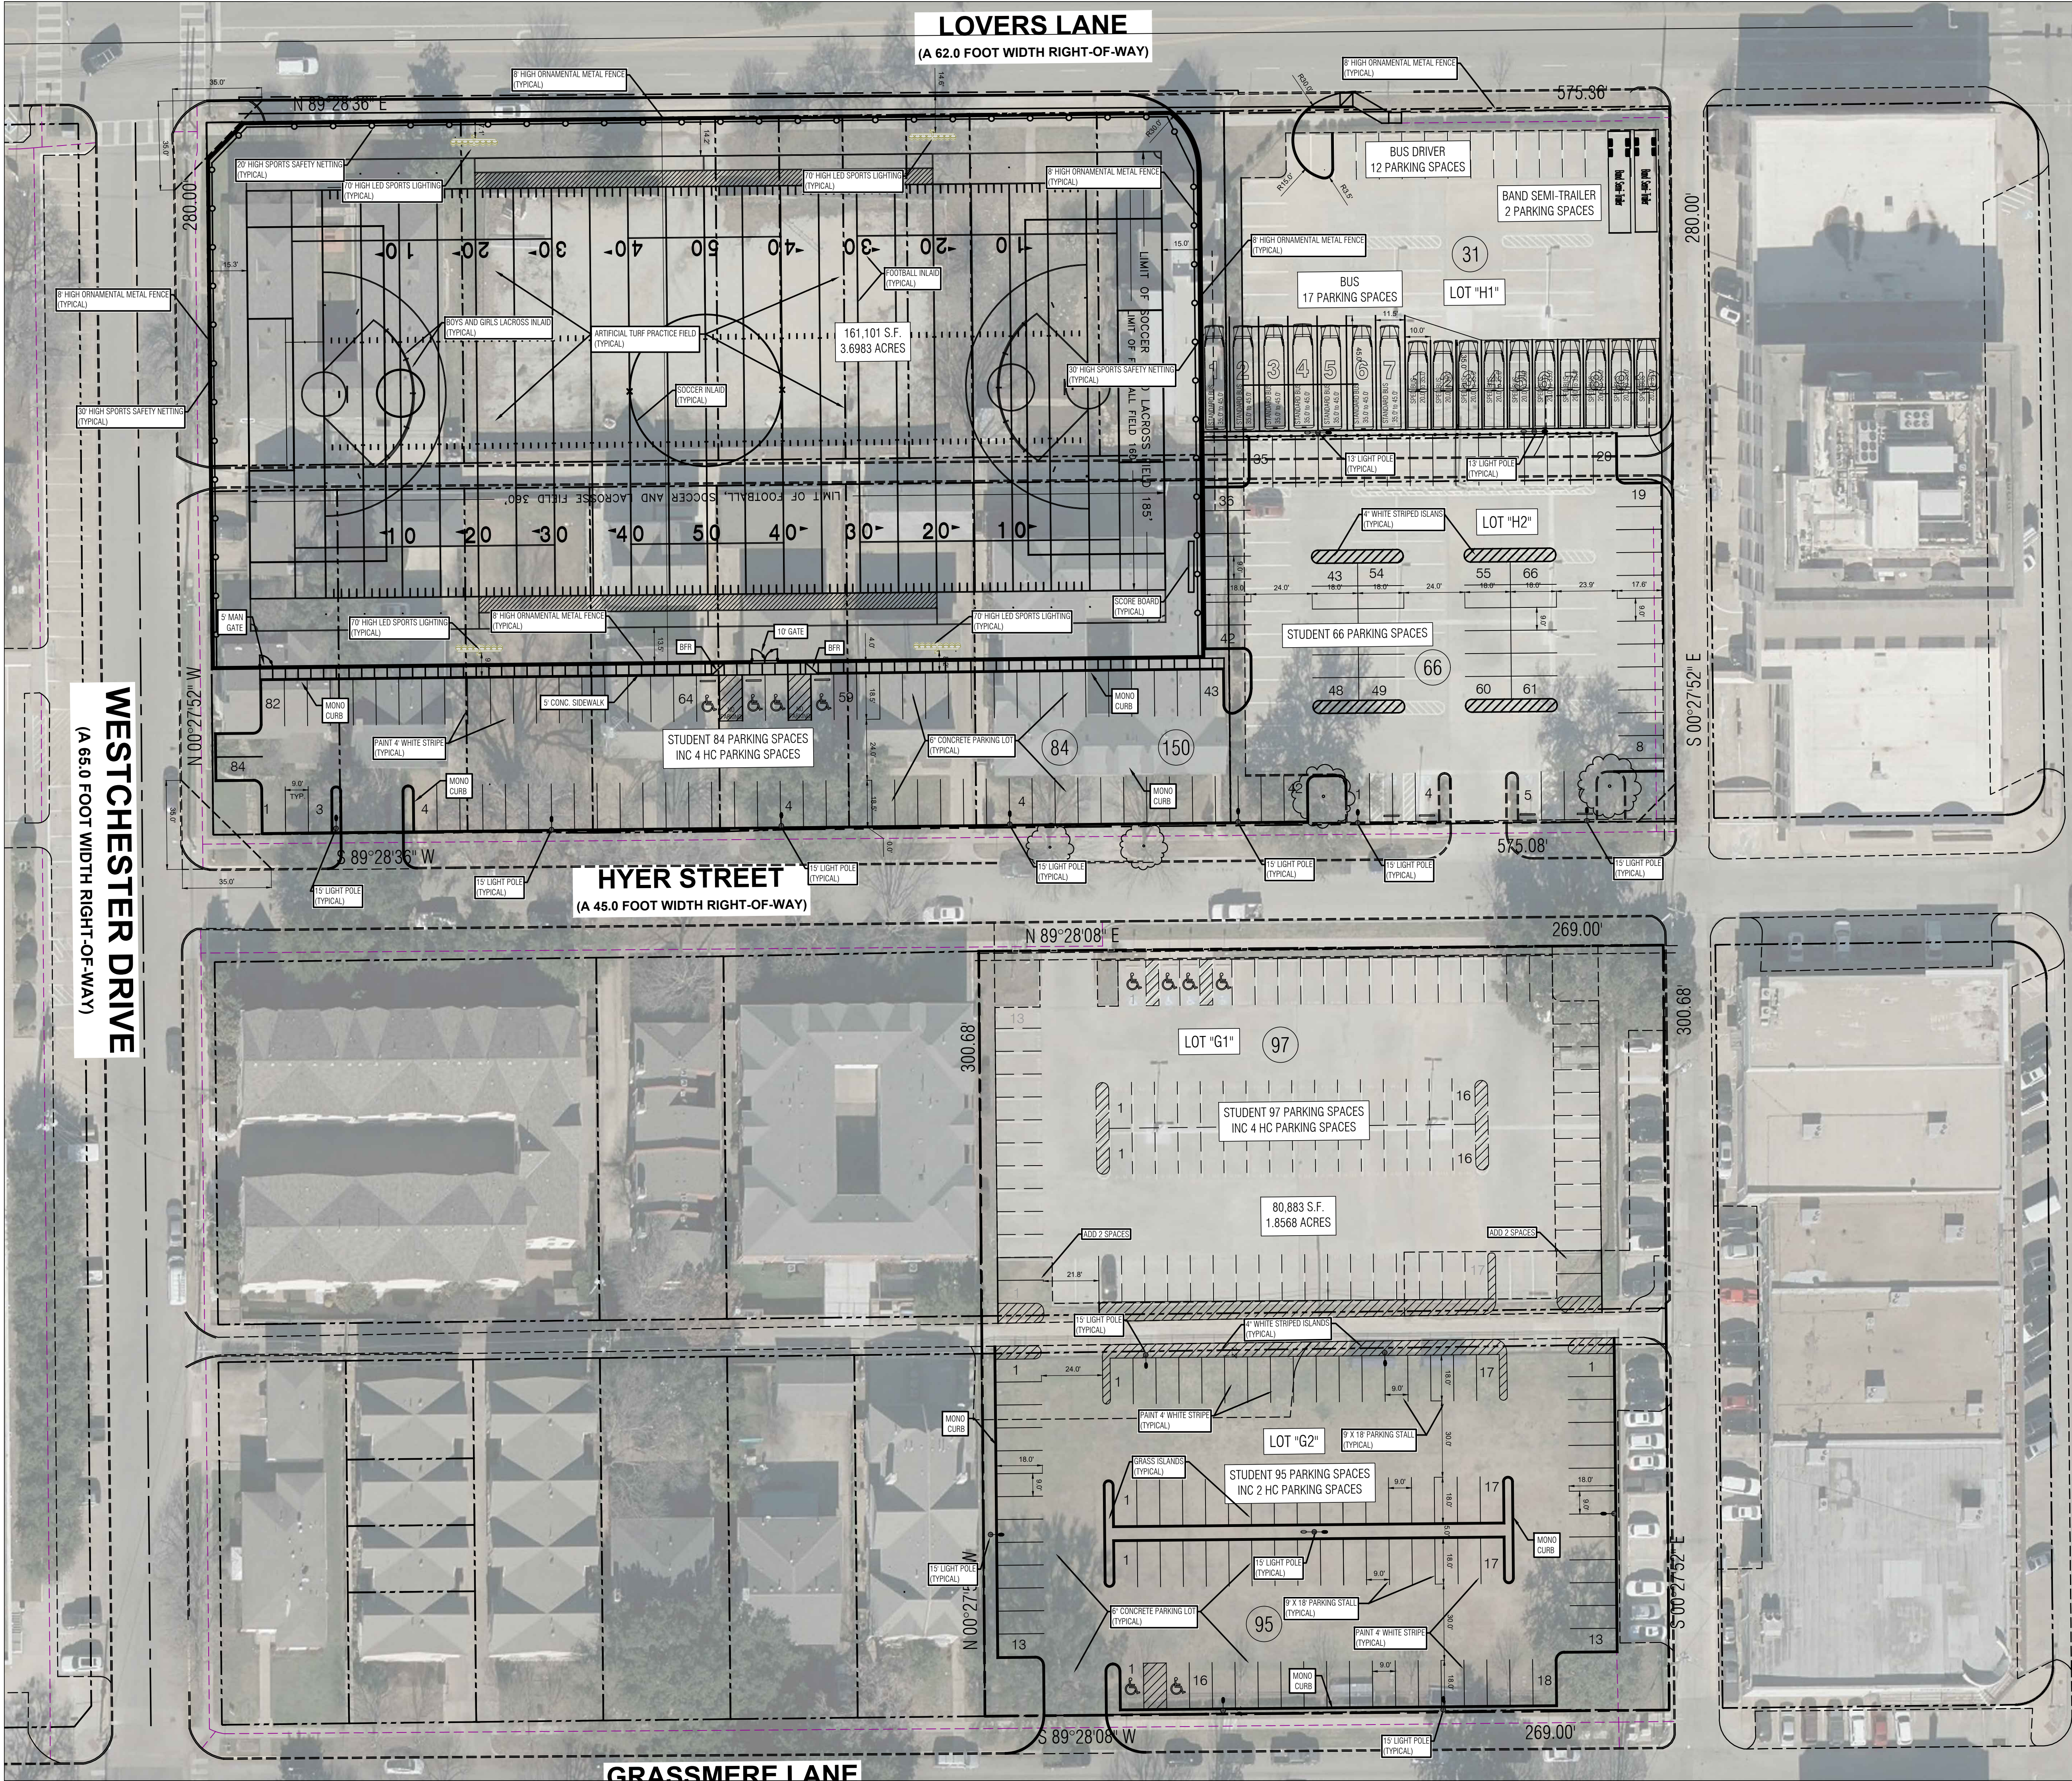

EXISTING STUDENT PARKING (INCLUDING HANDICAP SPACES)	
LOT "H1"	59 SPACES
LOT "H2"	47 SPACES
LOT "G1"	98 SPACES
TOTAL PARKING IN 3 LOTS	204 SPACES

PROPOSED STUDENT PARKING (INCLUDING HANDICAP SPACES)	
LOT "H1" TO BUS LOT	-59 SPACES
LOT "H2" RECONFIGURATION	150 SPACES
LOT "G1" RECONFIGURATION	97 SPACES
LOT "G2"(NEW GRASSMERE LOT)	95 SPACES
TOTAL PARKING	342 SPACES
NET INCREASE	283 SPACES



VLK | ARCHITECTS

ARCHITECT

VLK Architects, Inc.
5801 Tennyson Pkwy., Suite 100
Plano, Texas 75024
Main Phone: 972.265.1885
www.vlkarchitects.com

CIVIL ENGINEER

Glenn Engineering
TBPE Firm F-303
HUB #1752575163300
4500 Fuller Drive, Suite 220
Irving, Texas 75038
Main Phone: 972.717.5151
www.glennengineering.com


HIGHLAND PARK HIGH SCHOOL CAMPUS

THIS DOCUMENT IS RELEASED
FOR THE PURPOSE OF INTERIM
REVIEW UNDER THE AUTHORITY OF
MIKE GLENN, P.E. 35059,
ON February 6, 2026
IT IS NOT TO BE USED FOR
CONSTRUCTION PURPOSES

REVISIONS	
Revision No.	
Director	CMA
Approver	CMA
Designer	GEC
Proj. Arch.	GEC
Checker	RMR

PROJECT NO.	
SHEET TITLE	
DETAILED SITE PLAN	
SHEET NO.	

C03.01

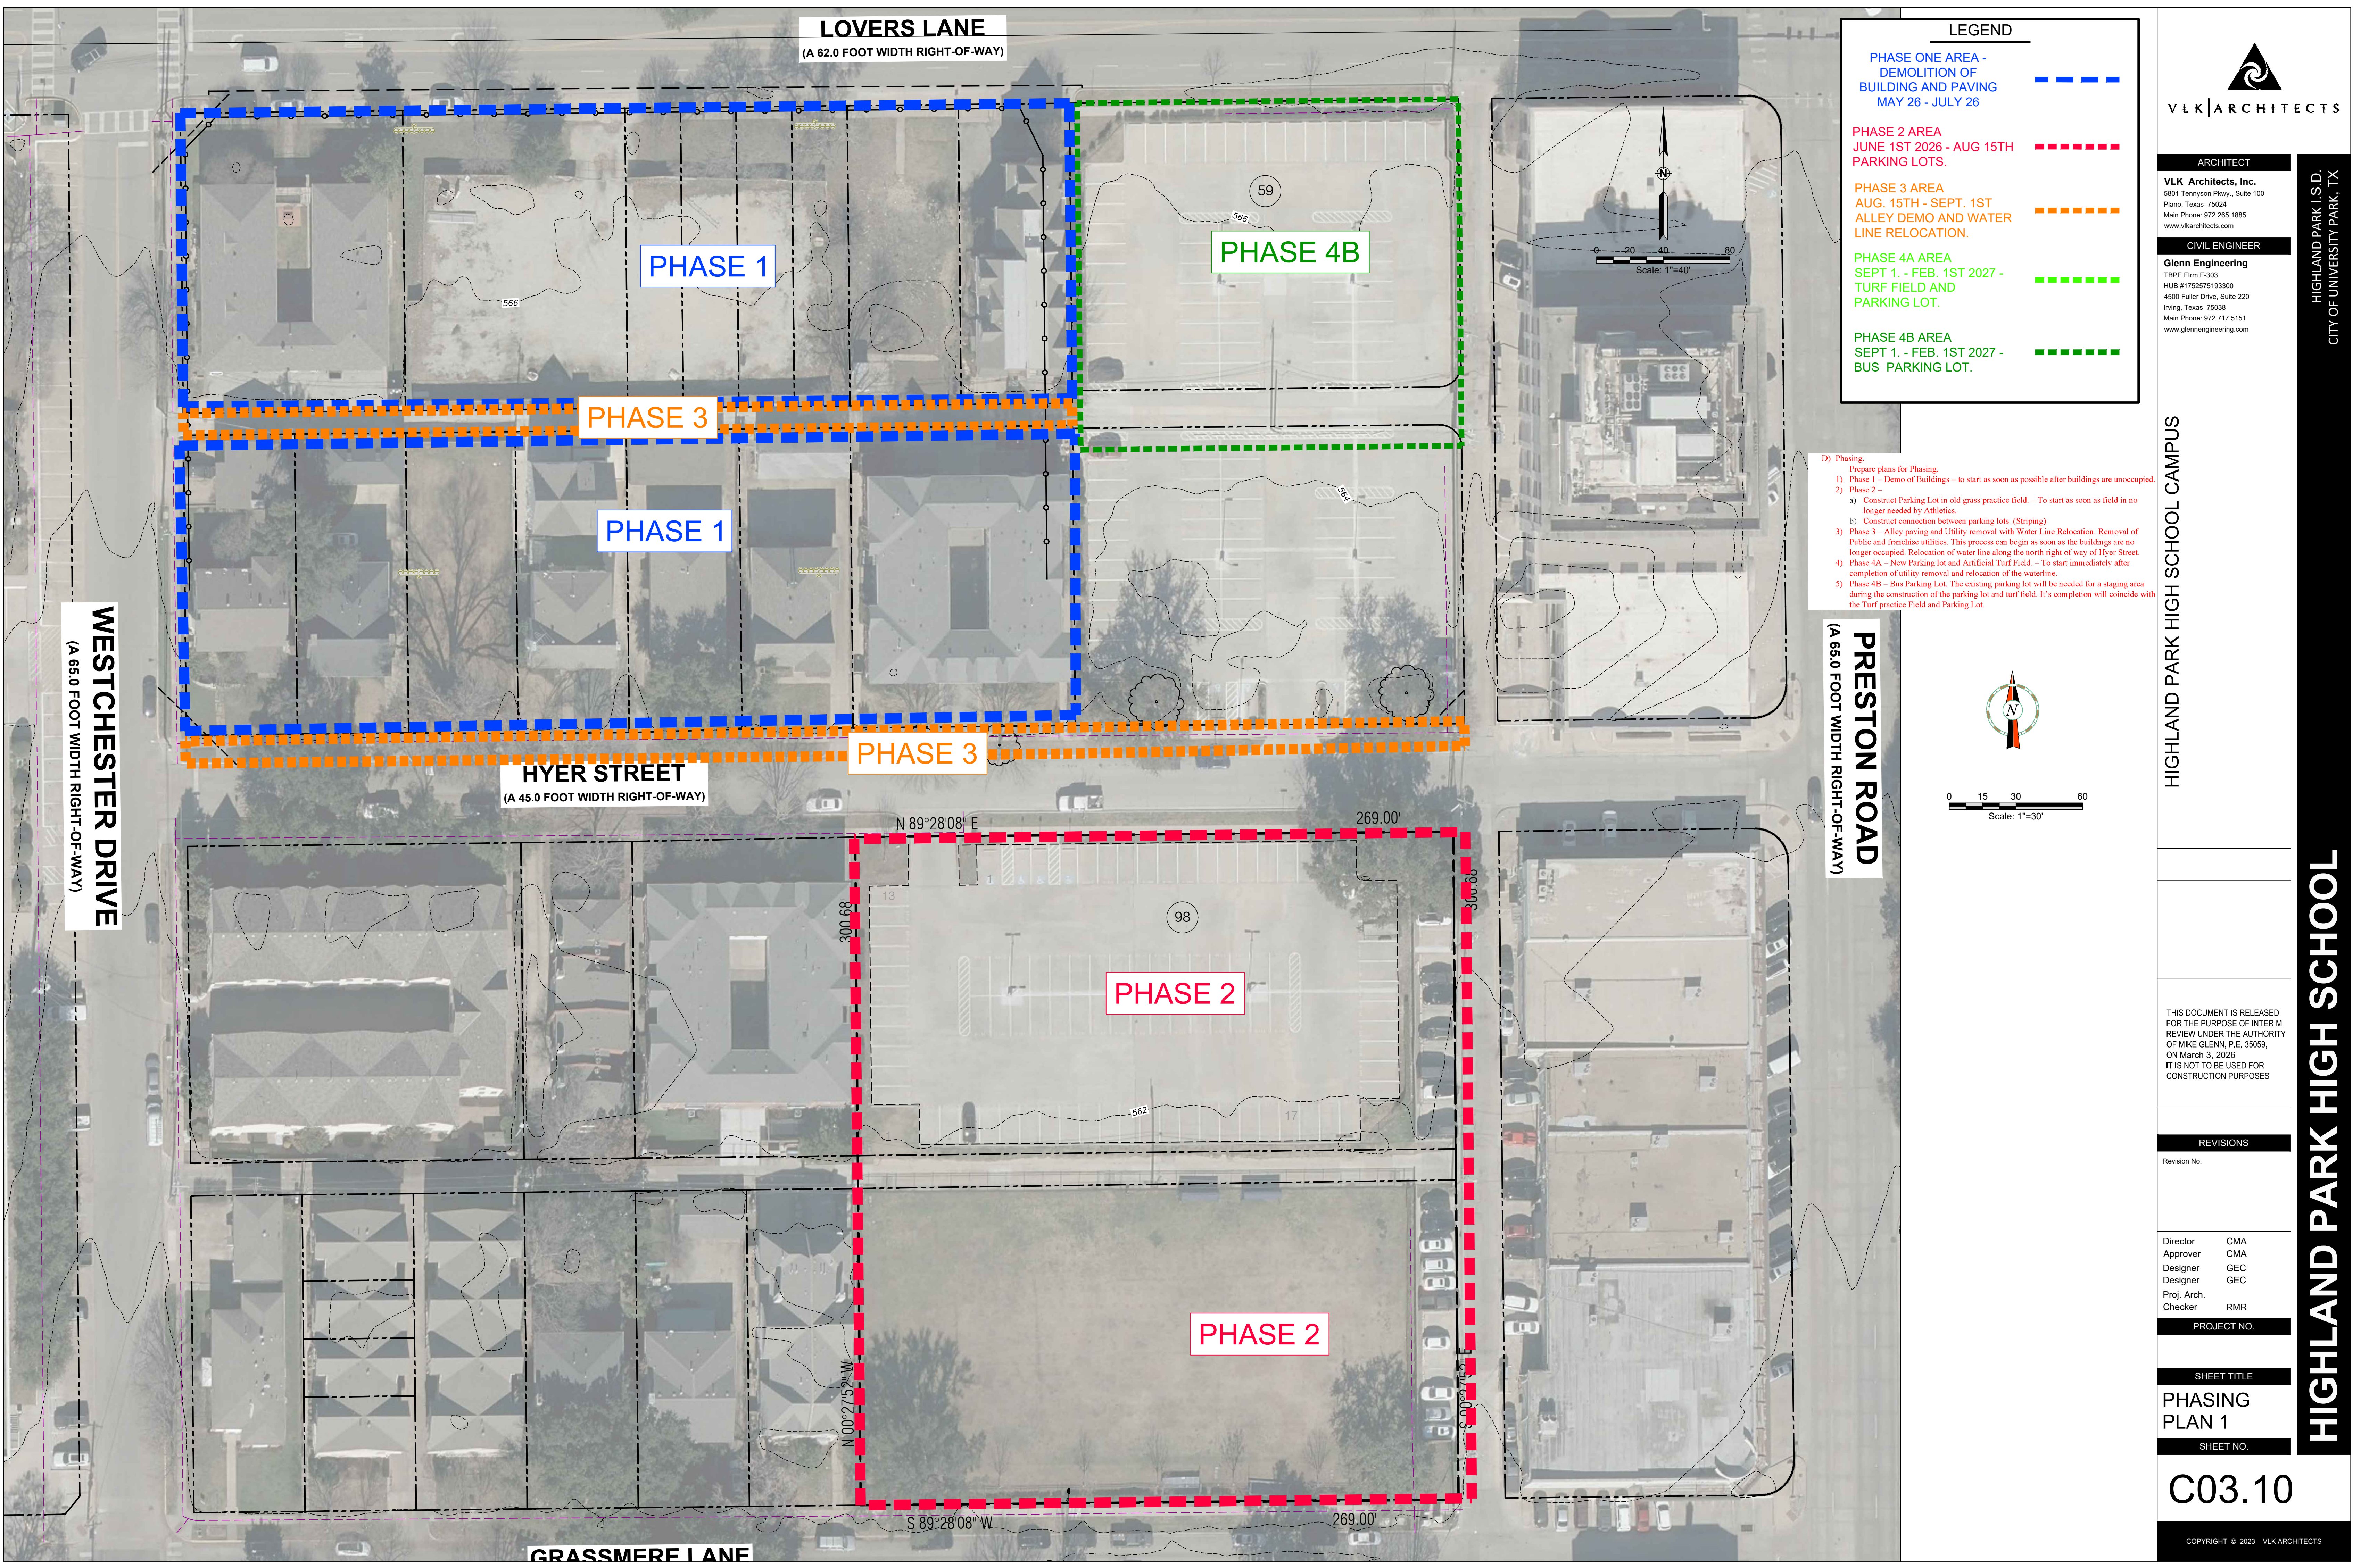

LEGEND

PHASE ONE AREA -
DEMOLITION OF
BUILDING AND PAVING
MAY 26 - JULY 26

PHASE 2 AREA
JUNE 1ST 2026 - AUG 15TH
PARKING LOTS.

PHASE 3 AREA
AUG. 15TH - SEPT. 1ST
ALLEY DEMO AND WATER
LINE RELOCATION.

PHASE 4A AREA
SEPT 1. - FEB. 1ST 2027 -
TURF FIELD AND
PARKING LOT.

PHASE 4B AREA
SEPT 1. - FEB. 1ST 2027 -
BUS PARKING LOT.

- D) Phasing
- Prepare plans for Phasing.
- 1) Phase 1 – Demo of Buildings – to start as soon as possible after buildings are unoccupied.
 - 2) Phase 2 –
 - a) Construct Parking Lot in old grass practice field. – To start as soon as field is no longer needed by Athletics.
 - b) Construct connection between parking lots. (Striping)
 - 3) Phase 3 – Alley paving and Utility removal with Water Line Relocation. Removal of Public and franchise utilities. This process can begin as soon as the buildings are no longer occupied. Relocation of water line along the north right of way of Hyer Street.
 - 4) Phase 4A – New Parking lot and Artificial Turf Field. – To start immediately after completion of utility removal and relocation of the waterline.
 - 5) Phase 4B – Bus Parking Lot. The existing parking lot will be needed for a staging area during the construction of the parking lot and turf field. It's completion will coincide with the Turf practice Field and Parking Lot.

VLK ARCHITECTS

ARCHITECT

VLK Architects, Inc.
5801 Tennyson Pkwy., Suite 100
Plano, Texas 75024
Main Phone: 972.265.1885
www.vlkarchitects.com

CIVIL ENGINEER

Glenn Engineering
TBPE Firm F-303
HUB #17257193300
4500 Fuller Drive, Suite 220
Irving, Texas 75038
Main Phone: 972.717.5151
www.glennengineering.com

HIGHLAND PARK HIGH SCHOOL CAMPUS

THIS DOCUMENT IS RELEASED
FOR THE PURPOSE OF INTERIM
REVIEW UNDER THE AUTHORITY
OF MIKE GLENN, P.E. 35059,
ON March 3, 2026
IT IS NOT TO BE USED FOR
CONSTRUCTION PURPOSES

REVISIONS

Revision No.

Director CMA

Approver CMA

Designer GEC

Designer GEC

Proj. Arch. RMR

Checker RMR

PROJECT NO.

SHEET TITLE

PHASING
PLAN 1

SHEET NO.



C03.10

COPYRIGHT © 2023 VLK ARCHITECTS

HIGHLAND PARK I.S.D.
CITY OF UNIVERSITY PARK, TX

HIGHLAND PARK HIGH SCHOOL

(A 62.0 FOOT WIDTH RIGHT-OF-WAY)

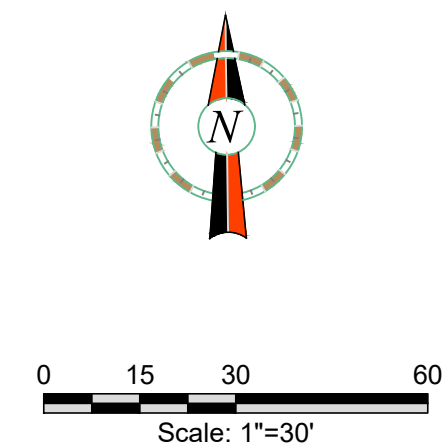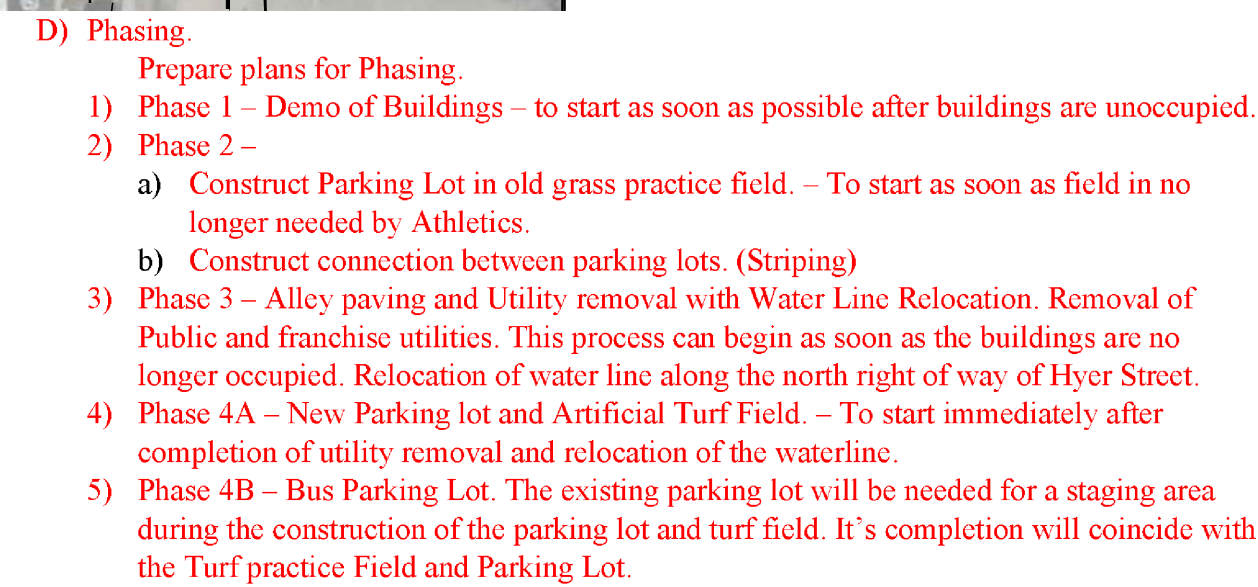

ARCHITECT

VLK Architects, Inc.
5801 Tennyson Pkwy., Suite 100
Plano, Texas 75024
Main Phone: 972.265.1885
www.vlkarchitects.com

CIVIL ENGINEER

Glenn Engineering

HUB #1752575193300
4500 Fuller Drive, Suite 220
Irving, Texas 75038
Main Phone: 972.717.5151
www.glennengineering.com

3

HIGHLAND PARK HIGH SCHOOL CAMPUS

HIGHLAND PARK HIGH SCHOOL

THIS DOCUMENT IS RELEASED
FOR THE PURPOSE OF INTERIM
REVIEW UNDER THE AUTHORITY
OF MIKE GLENN, P.E. 35059,
ON February 6, 2026
IT IS NOT TO BE USED FOR
CONSTRUCTION PURPOSES

REVISIONS

Revision No.

Director	CMA
Approver	CMA
Designer	GEC
Designer	GEC
Proj. Arch.	
Checker	RMR

PROJECT NC

SHEET TITLE


PHASING
PLAN 2

SHEET NO.

C03.11

COPYRIGHT © 2023 VLK ARCHITECTS

Mar 25, 2025 - 3:28pm User: Robert
D:\Public\Geo's Projects\HIGHLAND PARK\HIGHLAND PARK HIGH SCHOOL\BIDSET\2025 HP HS PARKING AND TURF ENG.dwg

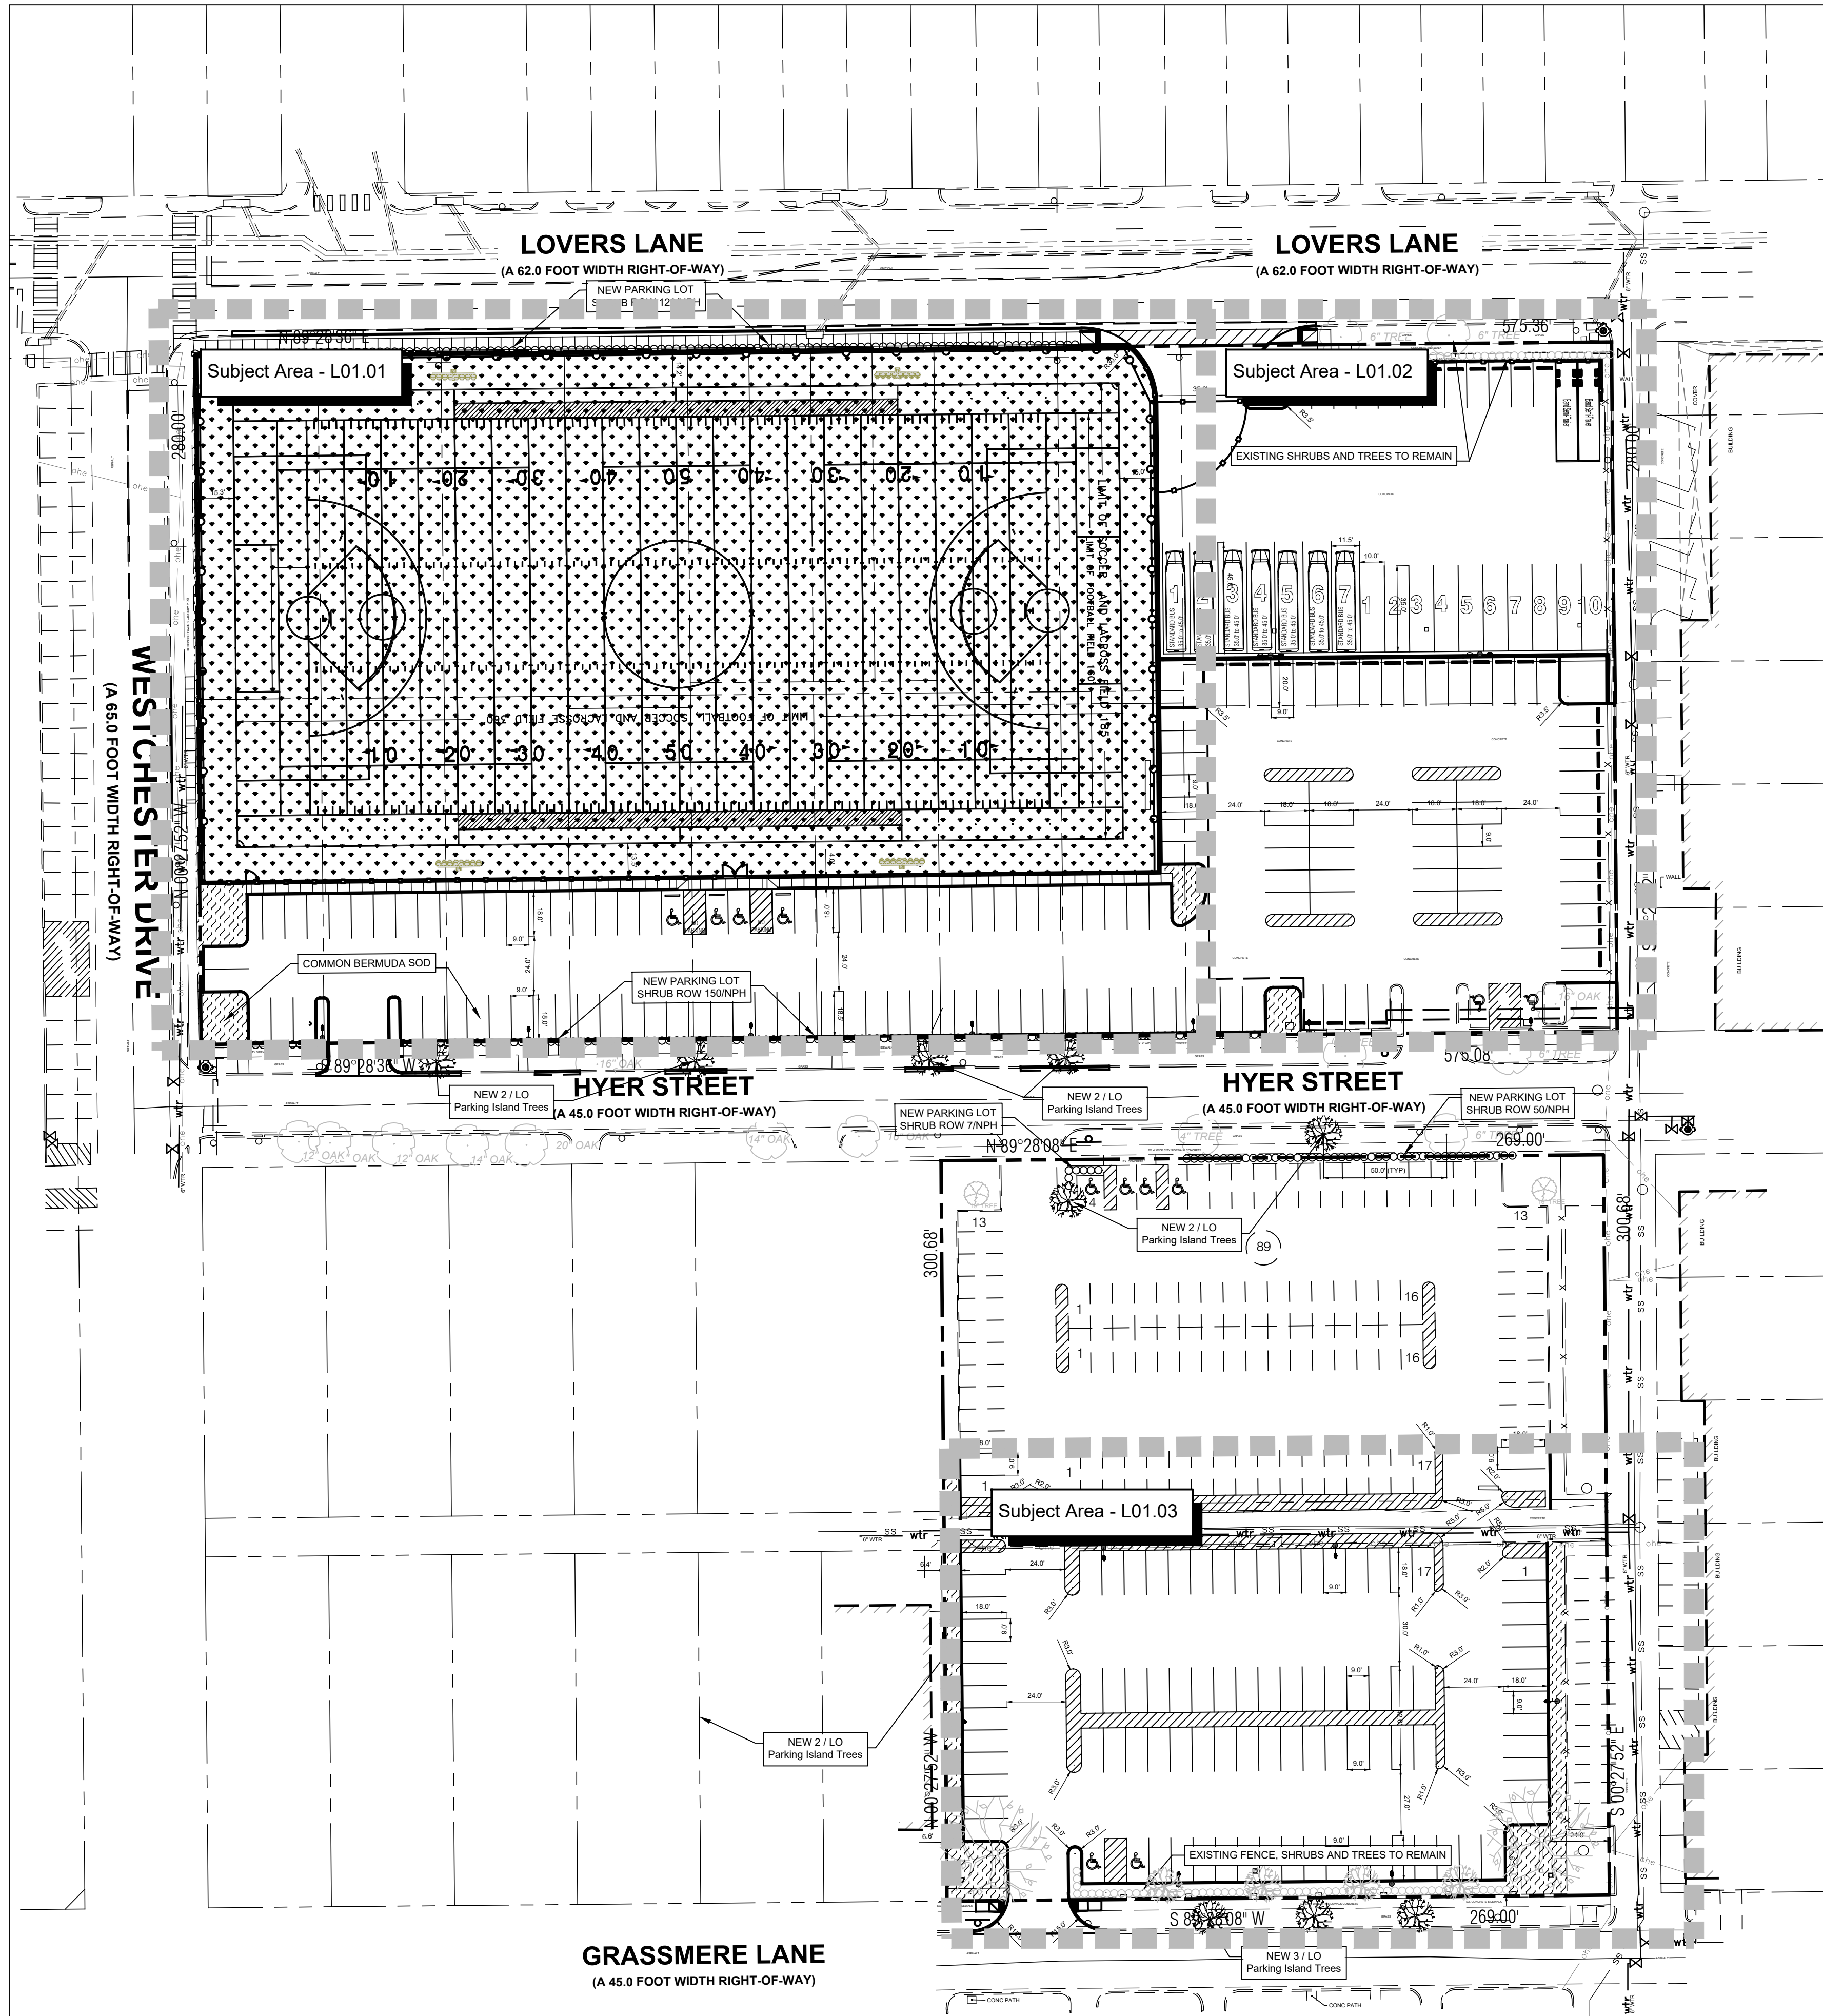

LANDSCAPE SCHEDULE					
USE	SYMBOL	COMMON NAME	MINIMUM SIZE/ HEIGHT/SPREAD	QUANTITIES	COMMENTS
SHRUBS		NEEDLE POINT HOLLY <i>Ilex Cornuta "Needle Point"</i>	HEIGHT/SPREAD RATIO = 3:2 24"x16" HT. MIN.	323 EA.	SEE LANDSCAPE PLAN AND ASSOCIATED DETAILS FOR LANDSCAPE BED LOCATIONS AND SHRUB SPACING
PARKING ISLAND TREES		CRAPE MYRTLE <i>Lagerstroemia Indica</i>	3" CALIPER (TOTAL) 6' HT.	0 EA.	SEE LANDSCAPE PLAN AND ASSOCIATED DETAILS FOR TREE PLACEMENT, AND PLANTING SPECIFICATIONS
		LIVE OAK <i>Quercus Phellos</i>	3" CALIPER 12' HT.	9 EA.	CONTRACTOR TO VERIFY TREE TYPE, LOCATION, SIZE, HEIGHT, AND SPREAD WITH QT REPRESENTATIVE PRIOR TO INSTALLATION
FILL TREES		CHINESE PISTACHE <i>Pistacia Chinesis</i>	3" CALIPER 12' HT.	0 EA.	
MISC.		ARTIFICIAL TURF		82,478 S.F.	
		COMMON BERMUDA GRASS		4,810 S.F.	

IRRIGATION NOTES:

- Contractor shall provide an irrigation system for the trees and shrubs based on specification section 32 80 00 Irrigation Specification. Also a single row of heads around the perimeter of the track.
- Contractor shall extend the existing Irrigation System at the existing parking lots to new landscaping.

SOLID SOD NOTES

- Fine grade areas to achieve final contours indicated. Leave areas to receive bed preparation 6" below final desired grade in planting areas and 3" below final grade in turf areas.
- Adjust contours to achieve positive drainage away from buildings. Provide uniform rounding at top and bottom of slopes and other breaks in grade. Correct irregularities and areas where water may stand.
- All lawn areas to receive solid sod shall be left in a maximum of 3" below final finish grade.
- All lawn areas to be fine graded, irrigation trenches completely settled, and finish grade approved by the Owner's Construction Manager or Architect prior to installation.
- All compacted soil shall be ripped and scarified to a minimum depth of 6" prior to fine grading.
- All rocks 3/4" diameter and larger, dirt clods, sticks, concrete spoils, etc. shall be removed prior to placing topsoil and any lawn installation.
- On site topsoil can be utilized for lawn area and planting bed backfill. If on-site topsoil is not sufficient enough to cover required areas, imported topsoil shall be brought in.
- When on-site topsoil is utilized, all rock, debris, stick, dirt clods etc. shall be removed.
- Plant sod by hand to cover indicated area completely. Insure edges of sod are touching. Top dress joints by hand with topsoil to fill voids.
- Roll grass areas to achieve a smooth, even surface, free from unnatural undulations.
- Water sod thoroughly as sod operation progresses.
- Contractor shall maintain all lawn areas until final acceptance. This shall include, but not limited to: mowing, watering, weeding, cultivating, cleaning and replacing dead or bare areas to keep plants in a vigorous, healthy condition.
- Contractor shall guarantee establishment of an acceptable turf area and shall provide replacement from local supply if necessary.

MAINTENANCE NOTES

- The Owner, tenant and their agent, if any, shall be jointly and severally responsible for the maintenance of all landscape.
- All landscape shall be maintained in a neat and orderly manner at all times. This shall include mowing, edging, pruning, fertilizing, watering, weeding and other such activities common to landscape maintenance.
- All landscape areas shall be kept free of trash, litter, weeds and other such material or plants not part of this plan.
- All plant material shall be maintained in a healthy and growing condition as is appropriate for the season of the year.
- All plant material which dies shall be replaced with plant material of equal or better value.
- Contractor shall provide separate bid proposal for one year's maintenance to begin after final acceptance.

LANDSCAPE NOTES

- Contractor shall verify all existing and proposed site elements and notify Architect of any discrepancies. Survey data of existing conditions was supplied by others.
- Contractor shall locate all existing underground utilities and notify Architect of any conflicts. Contractor shall exercise caution when working in the vicinity of underground utilities.
- Contractor is responsible for obtaining all required landscape and irrigation permits.
- Contractor to provide a minimum 2% slope away from all structures.
- All planting beds and lawn areas to be separated by Bend-A-Board Edging. No steel to be installed adjacent to sidewalks or curbs.
- All lawn areas to be Solid Sod "Turf" Bermudagrass, unless otherwise noted on the drawings.

TOTAL STUDENT PARKING (MINUS HANDICAP SPACES)	
SOUTH FIELD LOT	82 SPACES
LOT "H" RECONFIGURATION	23 SPACES
LOT "H" TO BUS LOT	-59 SPACES
GRASSMERE LOT	92 SPACES
NET INCREASE	138 SPACES

0 20 40 80
Scale: 1"=40'

ARCHITECT

VLK Architects, Inc.
5801 Tennyson Pkwy., Suite 100
Plano, Texas 75024
Main Phone: 972.265.1885
www.vlkarchitects.com

CIVIL ENGINEER

Glenn Engineering
TBPE Firm F-303
HUB #1752575193300
4500 Fuller Drive, Suite 220
Irving, Texas 75038
Main Phone: 972.717.5151
www.glennengineering.com

HIGHLAND PARK HIGH SCHOOL CAMPUS

THIS DOCUMENT IS RELEASED FOR THE PURPOSE OF INTERIM REVIEW UNDER THE AUTHORITY OF MIKE GLENN, P.E. 35059, ON March 25, 2026. IT IS NOT TO BE USED FOR CONSTRUCTION PURPOSES

REVISIONS	
Revision No.	
Director	CMA
Approver	CMA
Designer	GEC
Designer	GEC
Proj. Arch.	
Checker	RMR
PROJECT NO.	

SHEET TITLE	
OVERALL LANDSCAPE PLAN	
SHEET NO.	

L01.00

COPYRIGHT © 2023 VLK ARCHITECTS

NOTE: THE CITY OF UNIVERSITY PARK CONSTRUCTION STANDARDS APPLY, WHETHER INDICATED ON THESE PLANS OR NOT.

NOTE: EROSION CONTROLS SHALL BE IN PLACE PRIOR TO THE DISTURBANCE OF ANY EXISTING SURFACE.

HIGHLAND PARK I.S.D.
CITY OF UNIVERSITY PARK, TX

HIGHLAND PARK HIGH SCHOOL



VLK Architects, Inc.
5801 Tennyson Pkwy., Suite 100
Plano, Texas 75024
Main Phone: 972.265.1885
www.vlkarchitects.com

TBPE Firm F-303
HUB #1752575193300
4500 Fuller Drive, Suite 220
Irving, Texas 75038
Main Phone: 972.717.5151
www.glennengineering.com

HIGHLAND PARK I.S.D.
CITY OF UNIVERSITY PARK, TX

HIGHLAND PARK HIGH SCHOOL CAMPUS

HIGHLAND PARK HIGH SCHOOL

THIS DOCUMENT IS RELEASED
FOR THE PURPOSE OF INTERIM
REVIEW UNDER THE AUTHORITY
OF MIKE GLENN, P.E. 35059,
ON March 25, 2026
IT IS NOT TO BE USED FOR
CONSTRUCTION PURPOSES

Revision No.



PROJECT NO.

LANDSCAPE

SHEET NO.

L01.01

COPYRIGHT © 2023 VLK ARCHITECTS

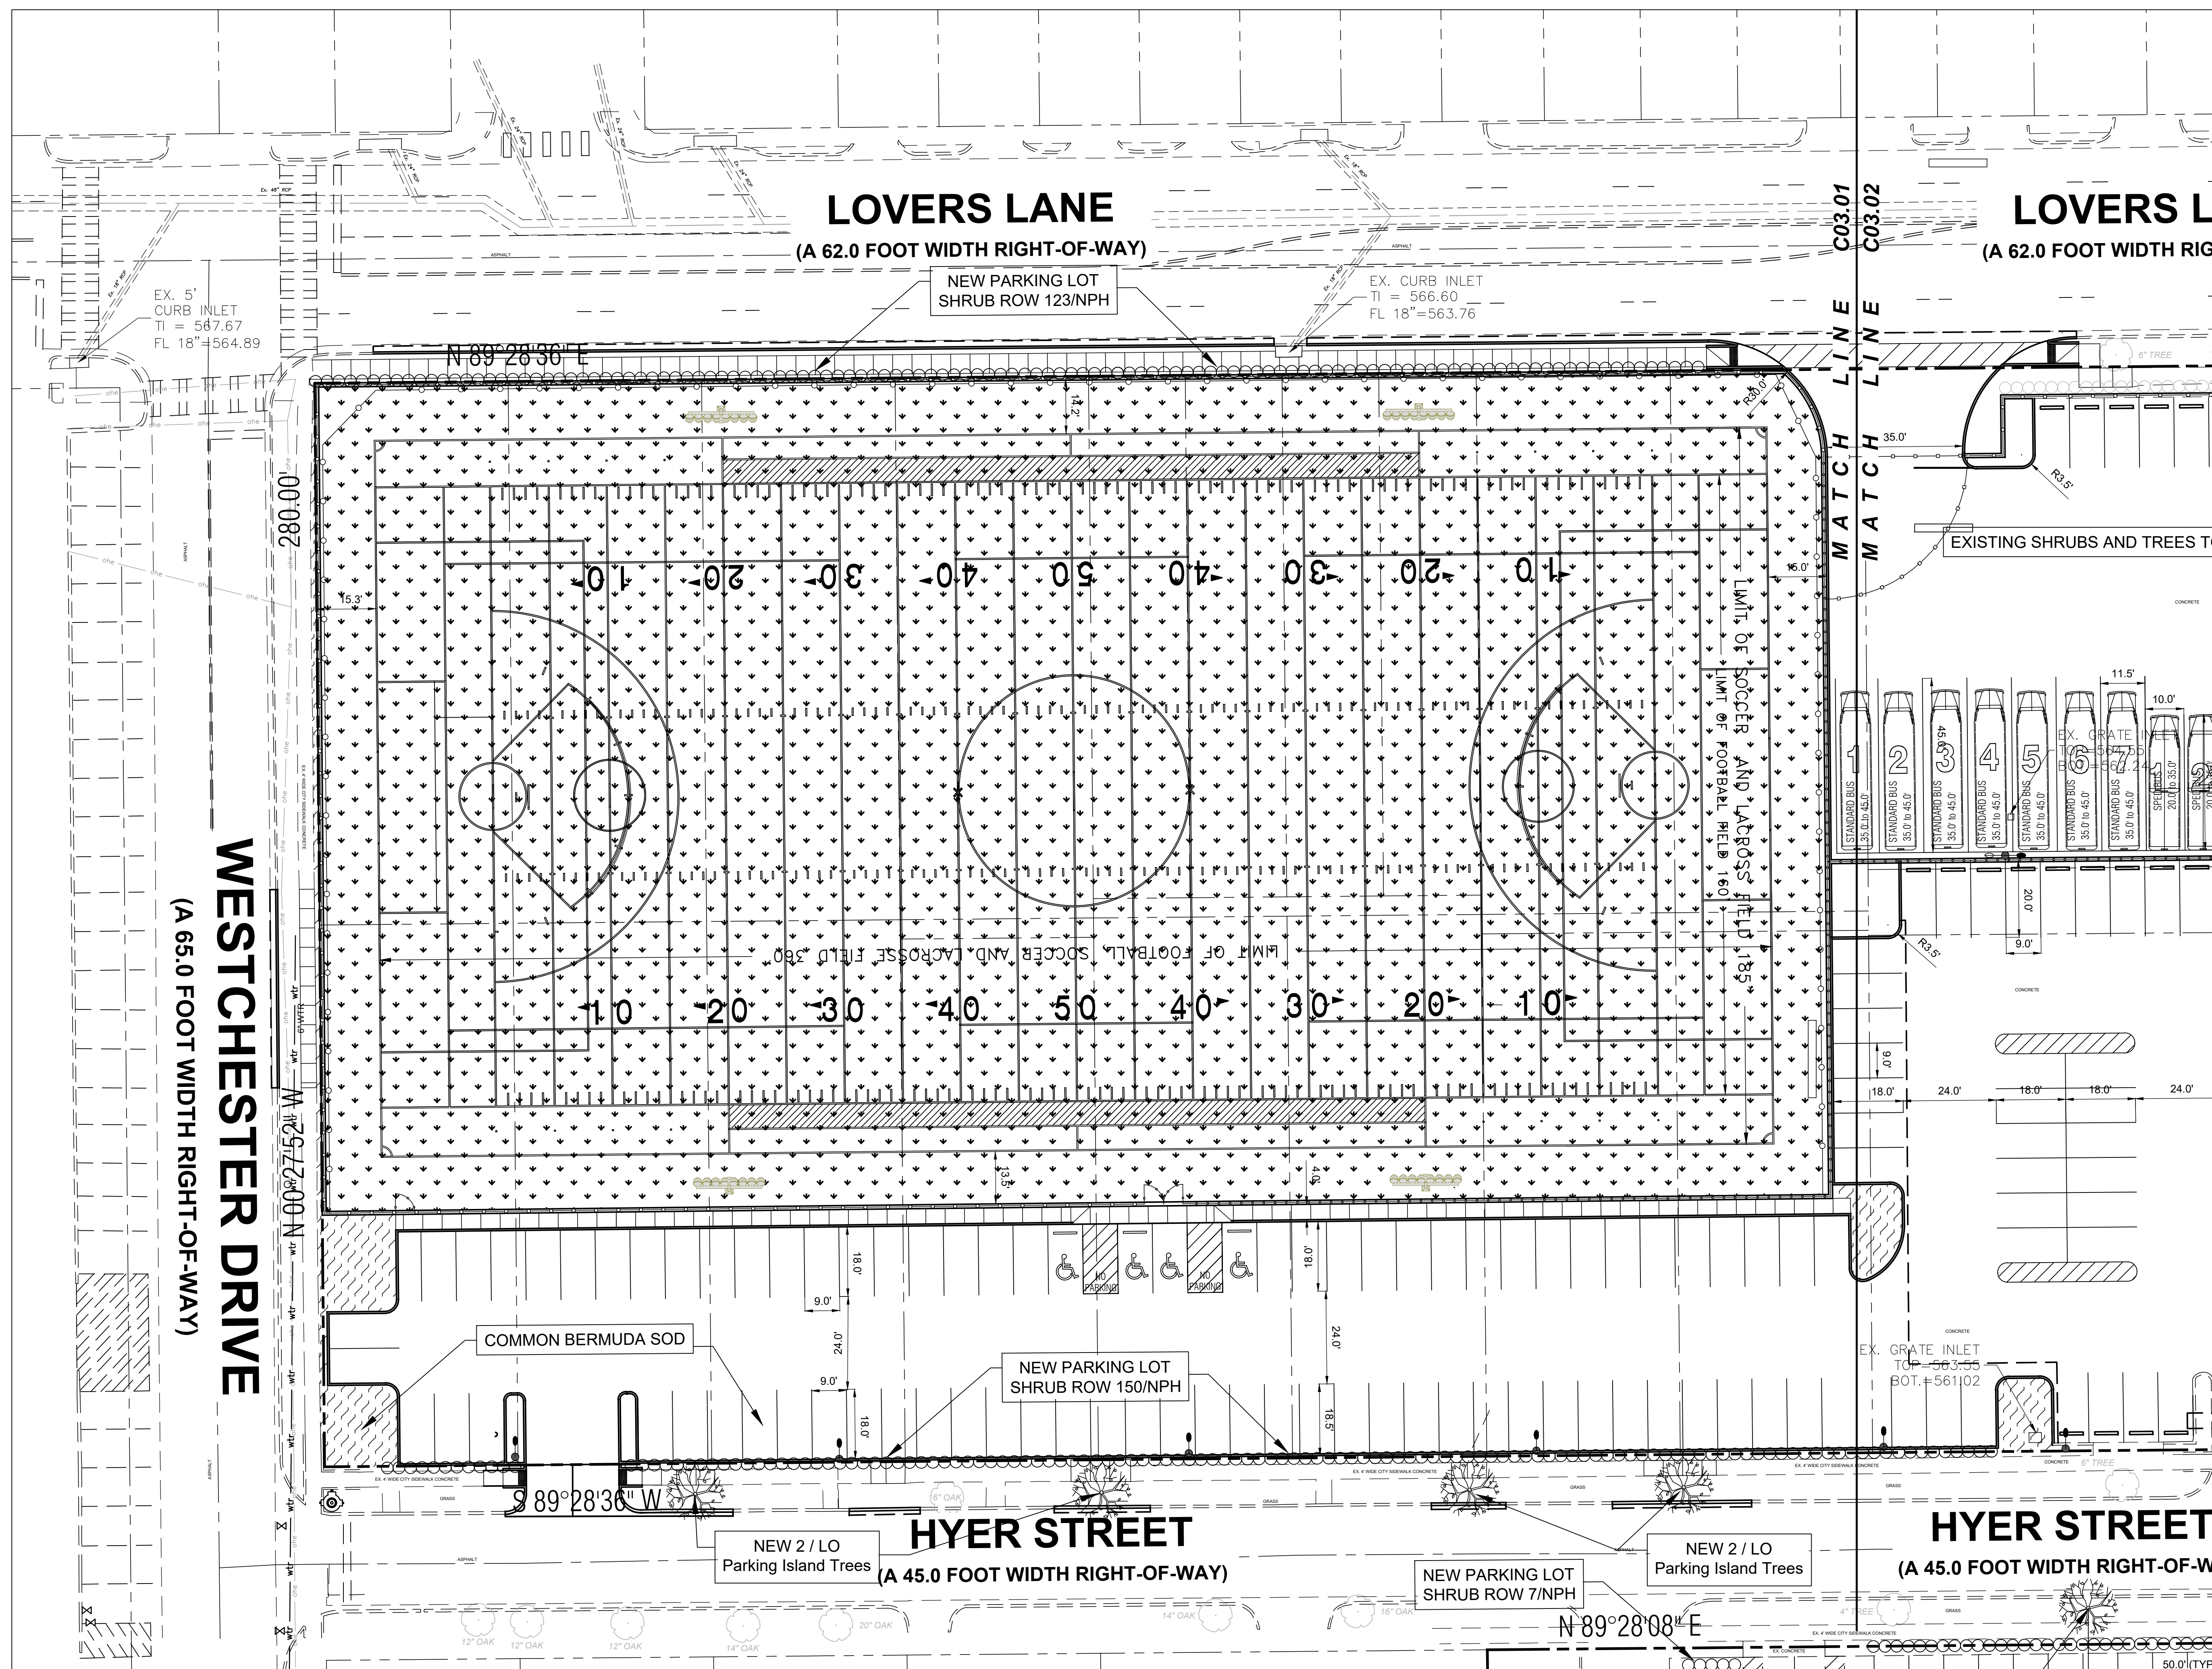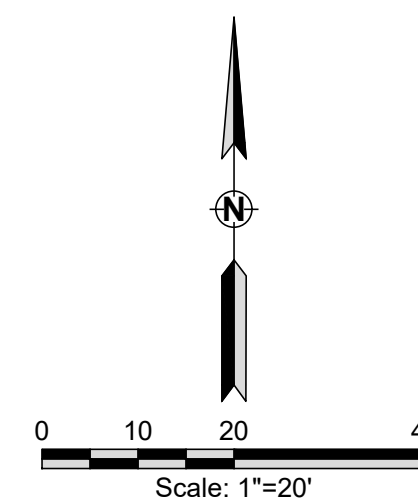

NOTE: THE CITY OF UNIVERSITY PARK CONSTRUCTION STANDARDS APPLY, WHETHER INDICATED ON THESE PLANS OR NOT.

NOTE: EROSION CONTROLS SHALL BE IN PLACE PRIOR TO THE DISTURBANCE OF ANY EXISTING SURFACE.



Mar 25, 2026 - 3:24pm User: Robert
D:\Public\Bob's Projects\HIGHLAND PARK\HIGHLAND PARK HIGH SCHOOL\BIDSET\2026 HP HS PARKING AND TURF ENG.dwg

HIGHLAND PARK HIGH SCHOOL

COPYRIGHT © 2023 VLK ARCHITECTS




EXISTING LEGEND (TO REMAIN)	
	Road Centerline
	Edge of Asphalt
	Overhead Electric
	Parking Striping
	Building
	Edge of Concrete
	Curb
	ADA Striping
	Water Valve
	Fire Hydrant
	Sanitary Manhole
	Light Pole
	TREE/CALIPER/TYPE

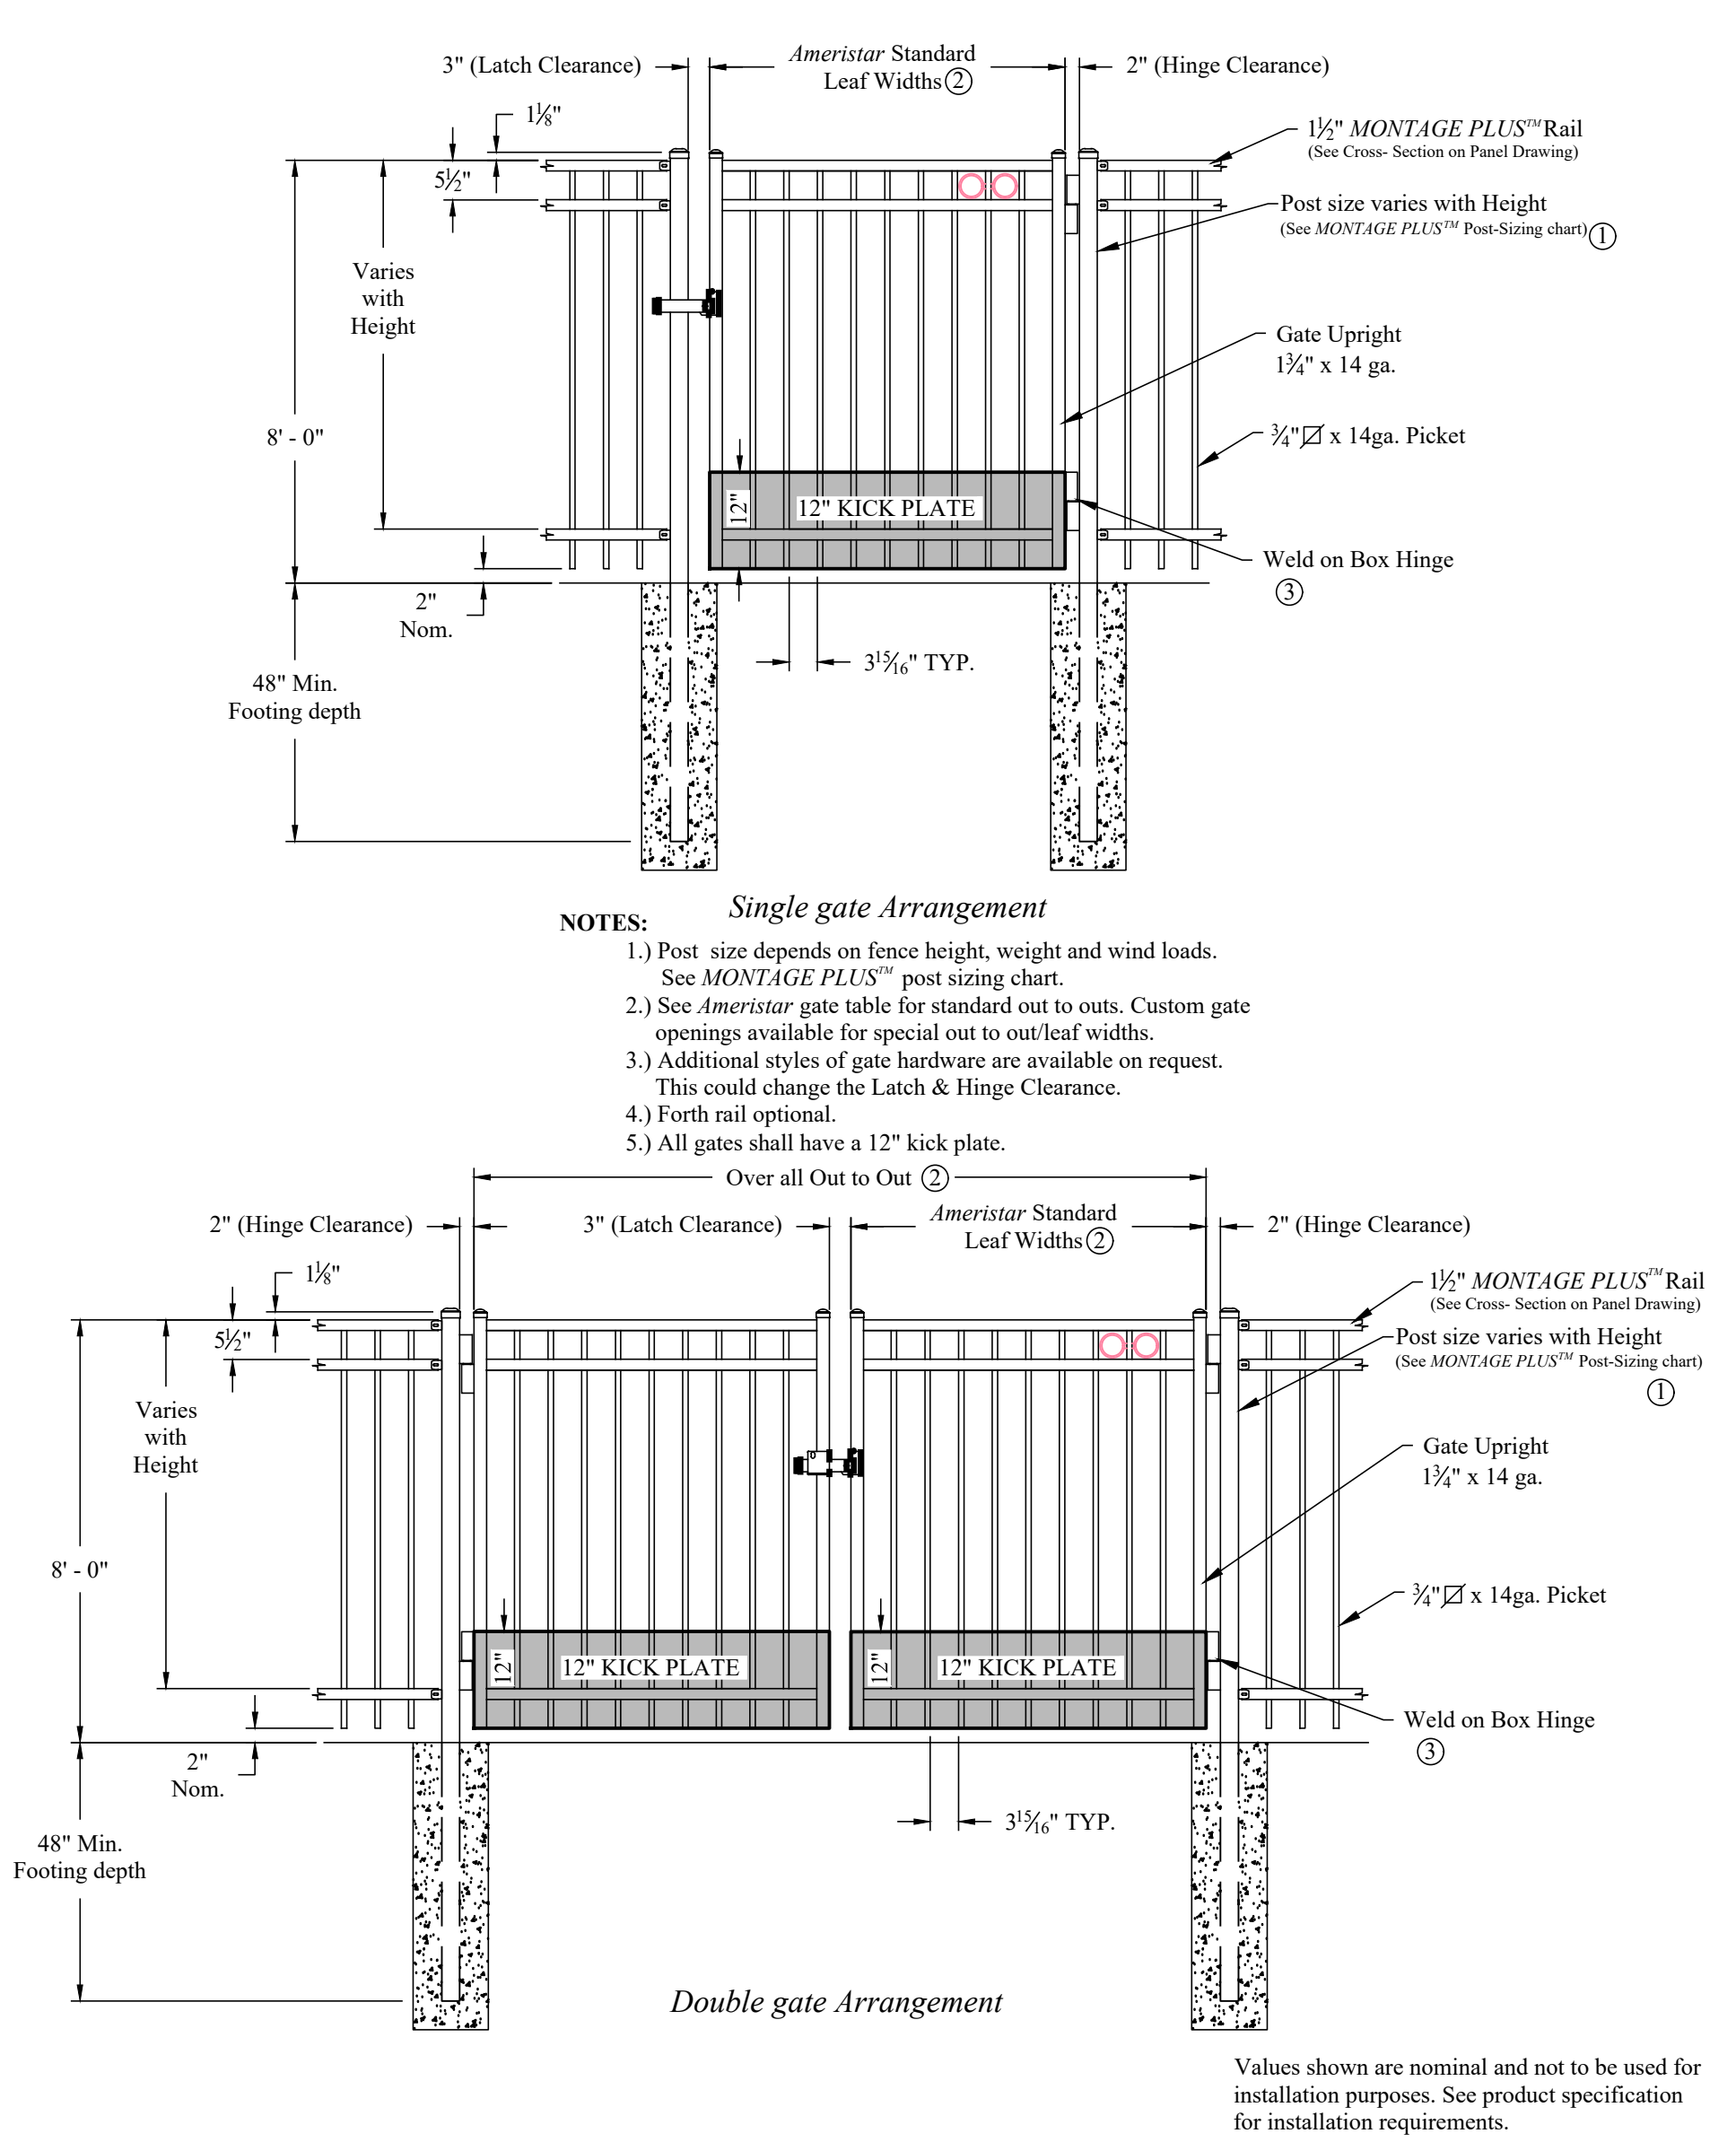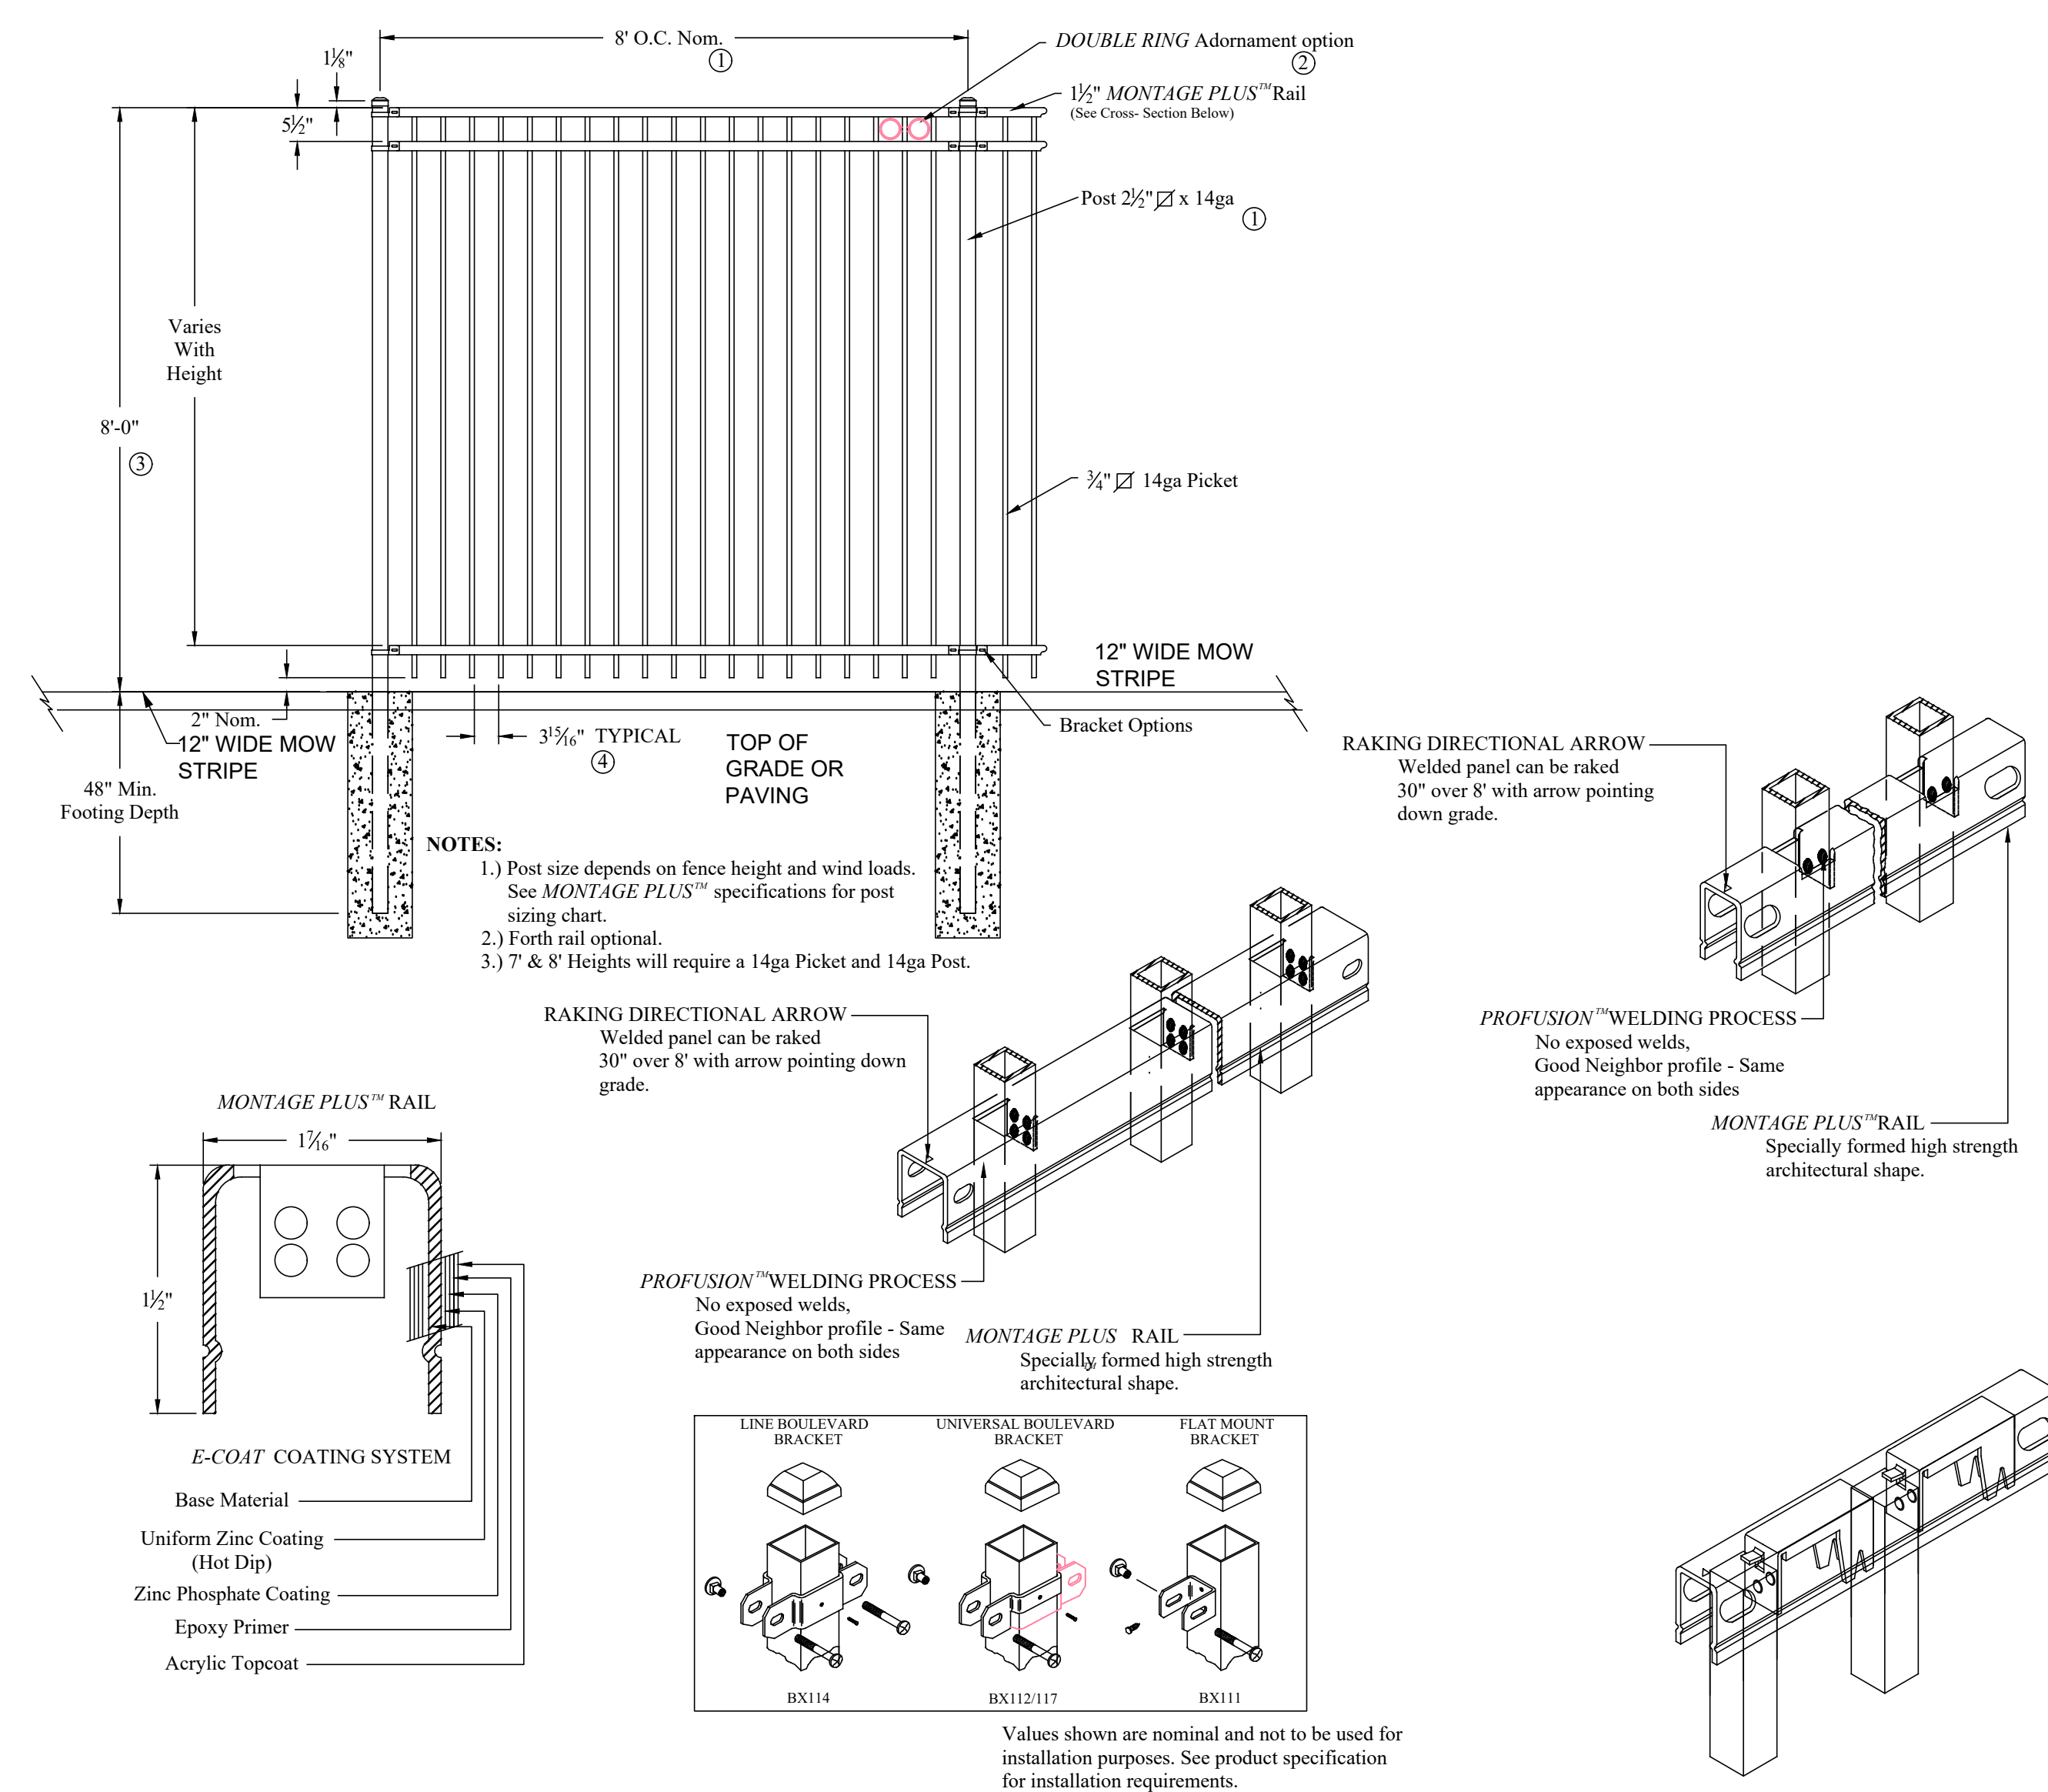


A1 METAL FENCE DETAILS
NTS SECTION "A-A"

A1 METAL FENCE DETAILS
NTS SECTION "A-A"

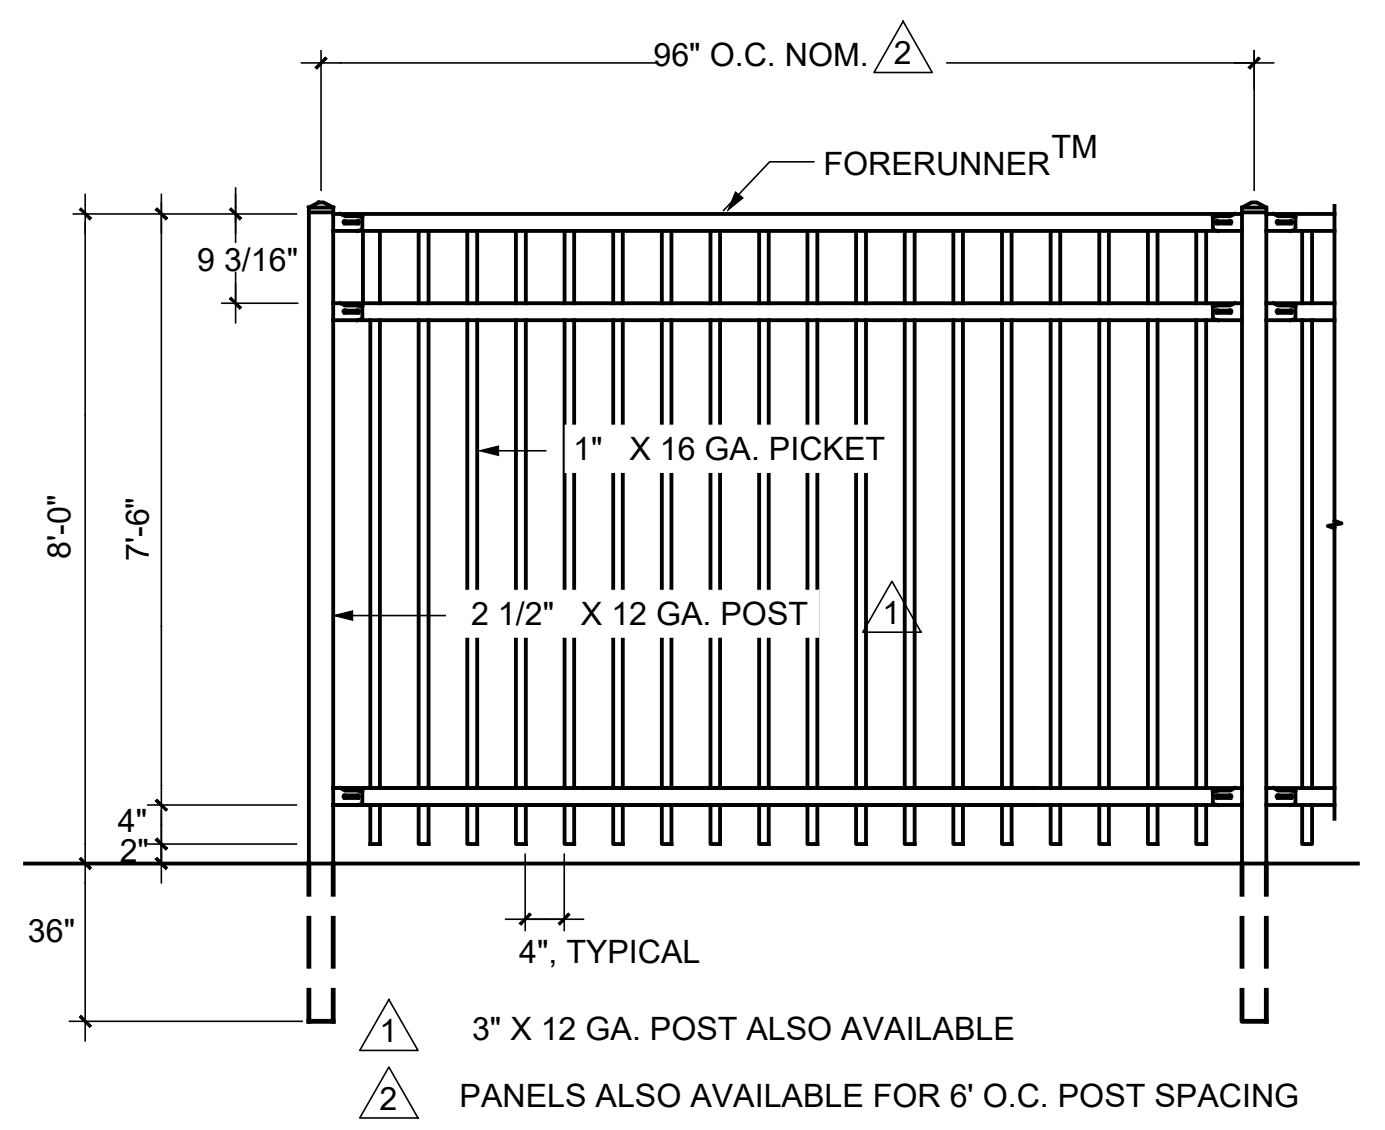

B1 ORNAMENTAL FENCE DETAIL
NTS

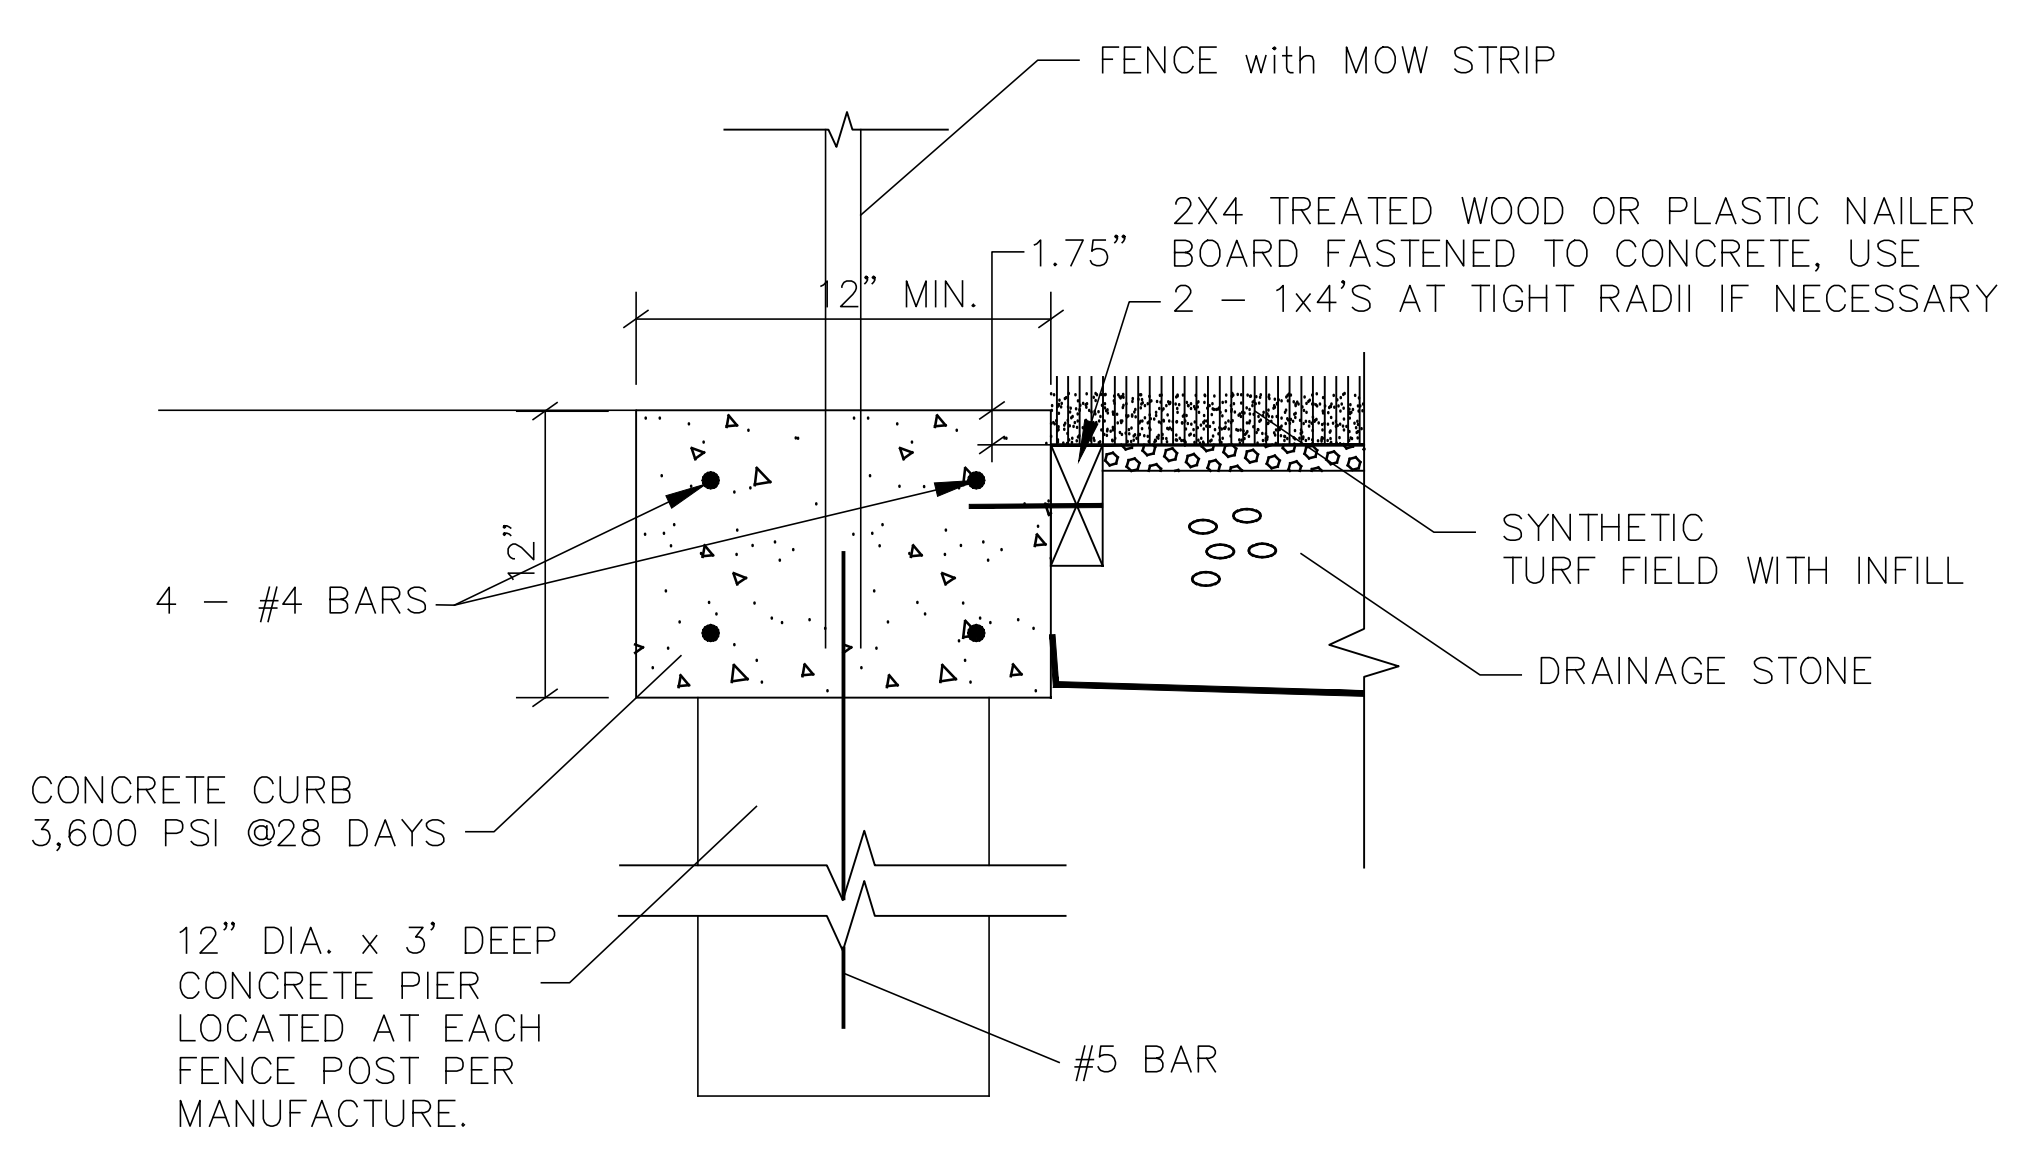

B1 ORNAMENTAL FENCE DETAIL WITH MOW STRIP
NTS PIER DEPTH PER MANUFACTURE

ARCHITECT

VLK Architects, Inc.
5801 Tennyson Pkwy., Suite 100
Plano, Texas 75024
Main Phone: 972.265.1885
www.vlkarchitects.com

CIVIL ENGINEER

Glenn Engineering
TBPE Firm F-303
HUB #175257193300
4500 Fuller Drive, Suite 220
Irving, Texas 75038
Main Phone: 972.717.5151
www.glennengineering.com

HIGHLAND PARK I.S.D.
CITY OF UNIVERSITY PARK, TX

HIGHLAND PARK HIGH SCHOOL CAMPUS

THIS DOCUMENT IS RELEASED
FOR THE PURPOSE OF INTERIM
REVIEW UNDER THE AUTHORITY
OF MIKE GLENN, P.E. 35059,
ON February 6, 2026
IT IS NOT TO BE USED FOR
CONSTRUCTION PURPOSES

REVISIONS

Revision No.

Director CMA
Approver CMA
Designer GEC
Designer GEC
Proj. Arch.
Checker RMR



PROJECT NO.



SHEET TITLE



SITE DETAILS -
NETTING

SHEET NO.

C03.21

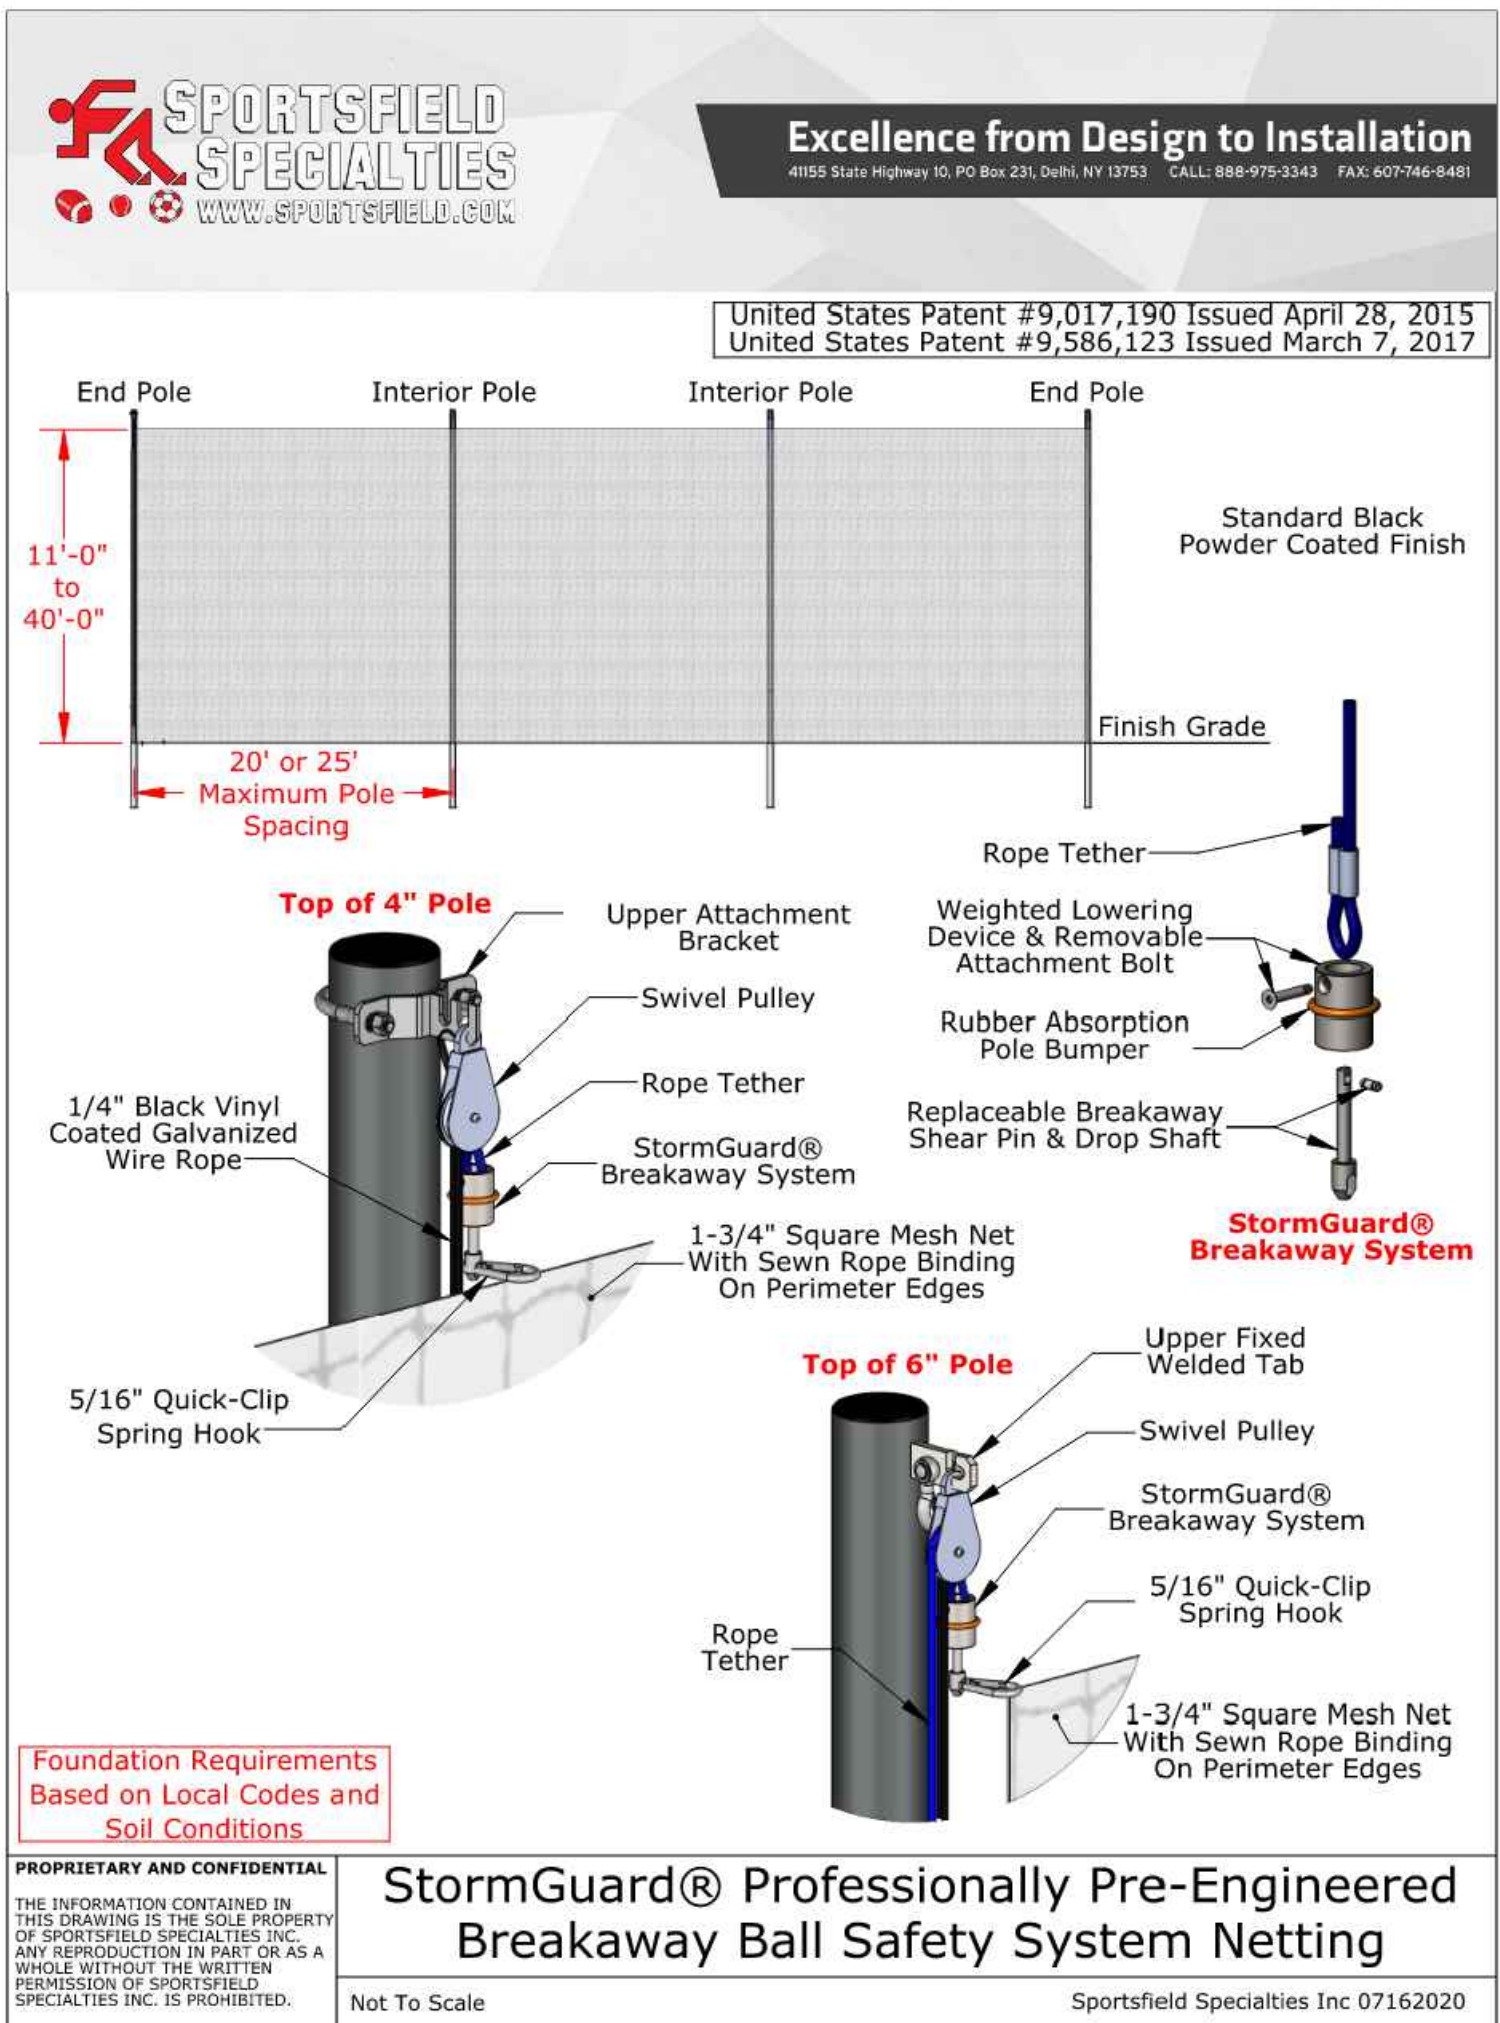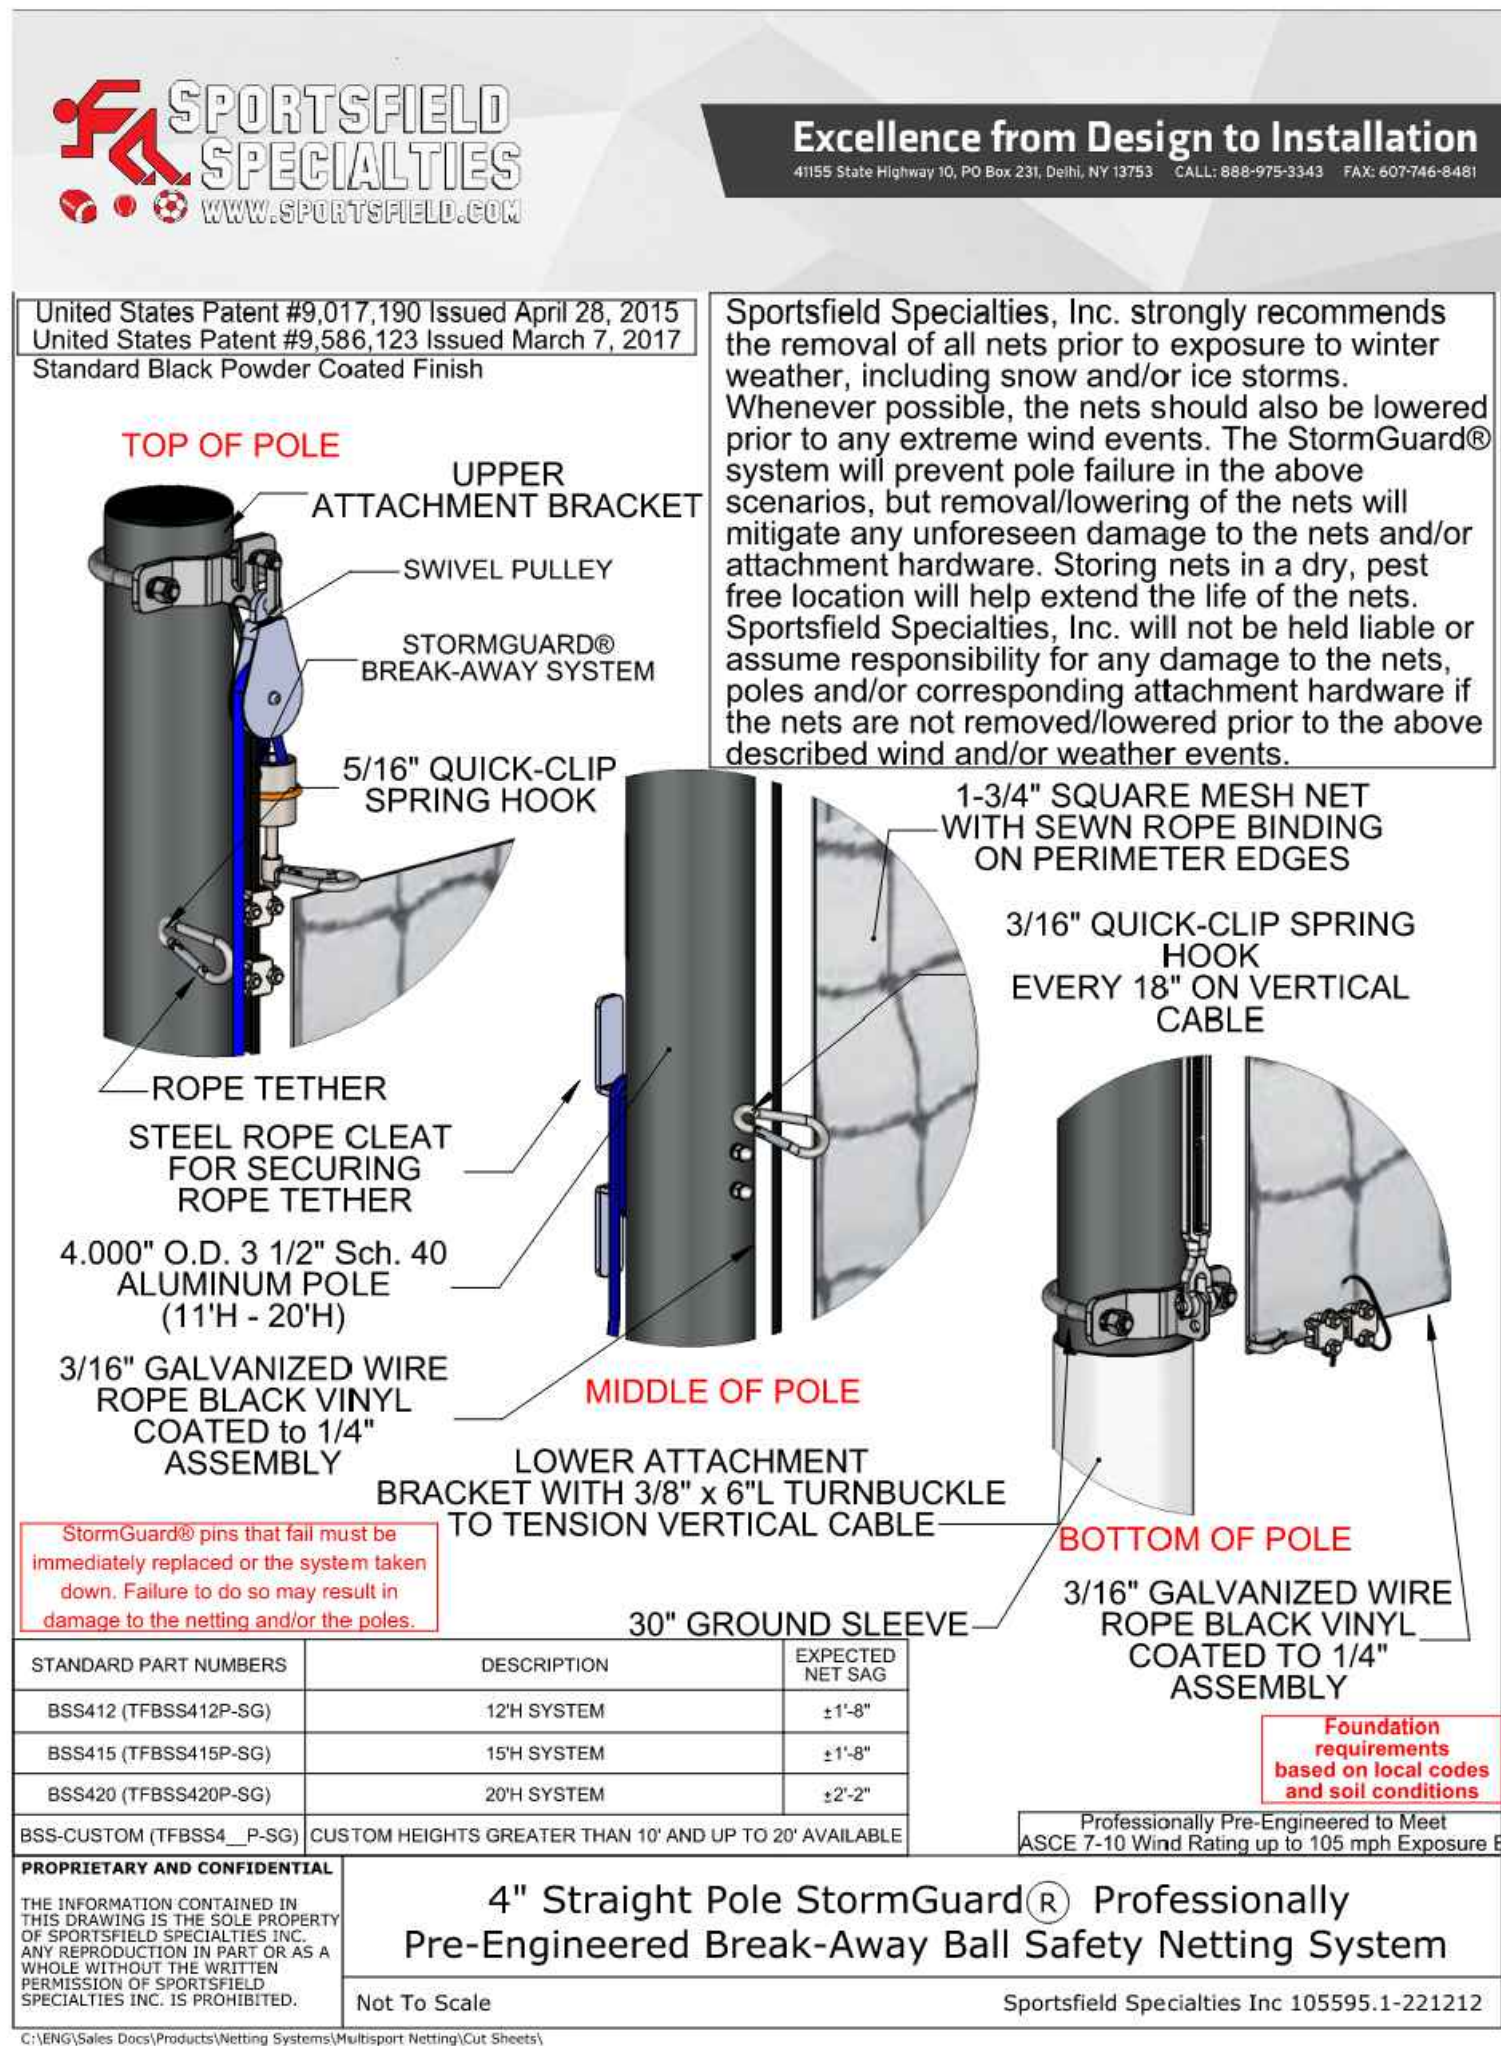

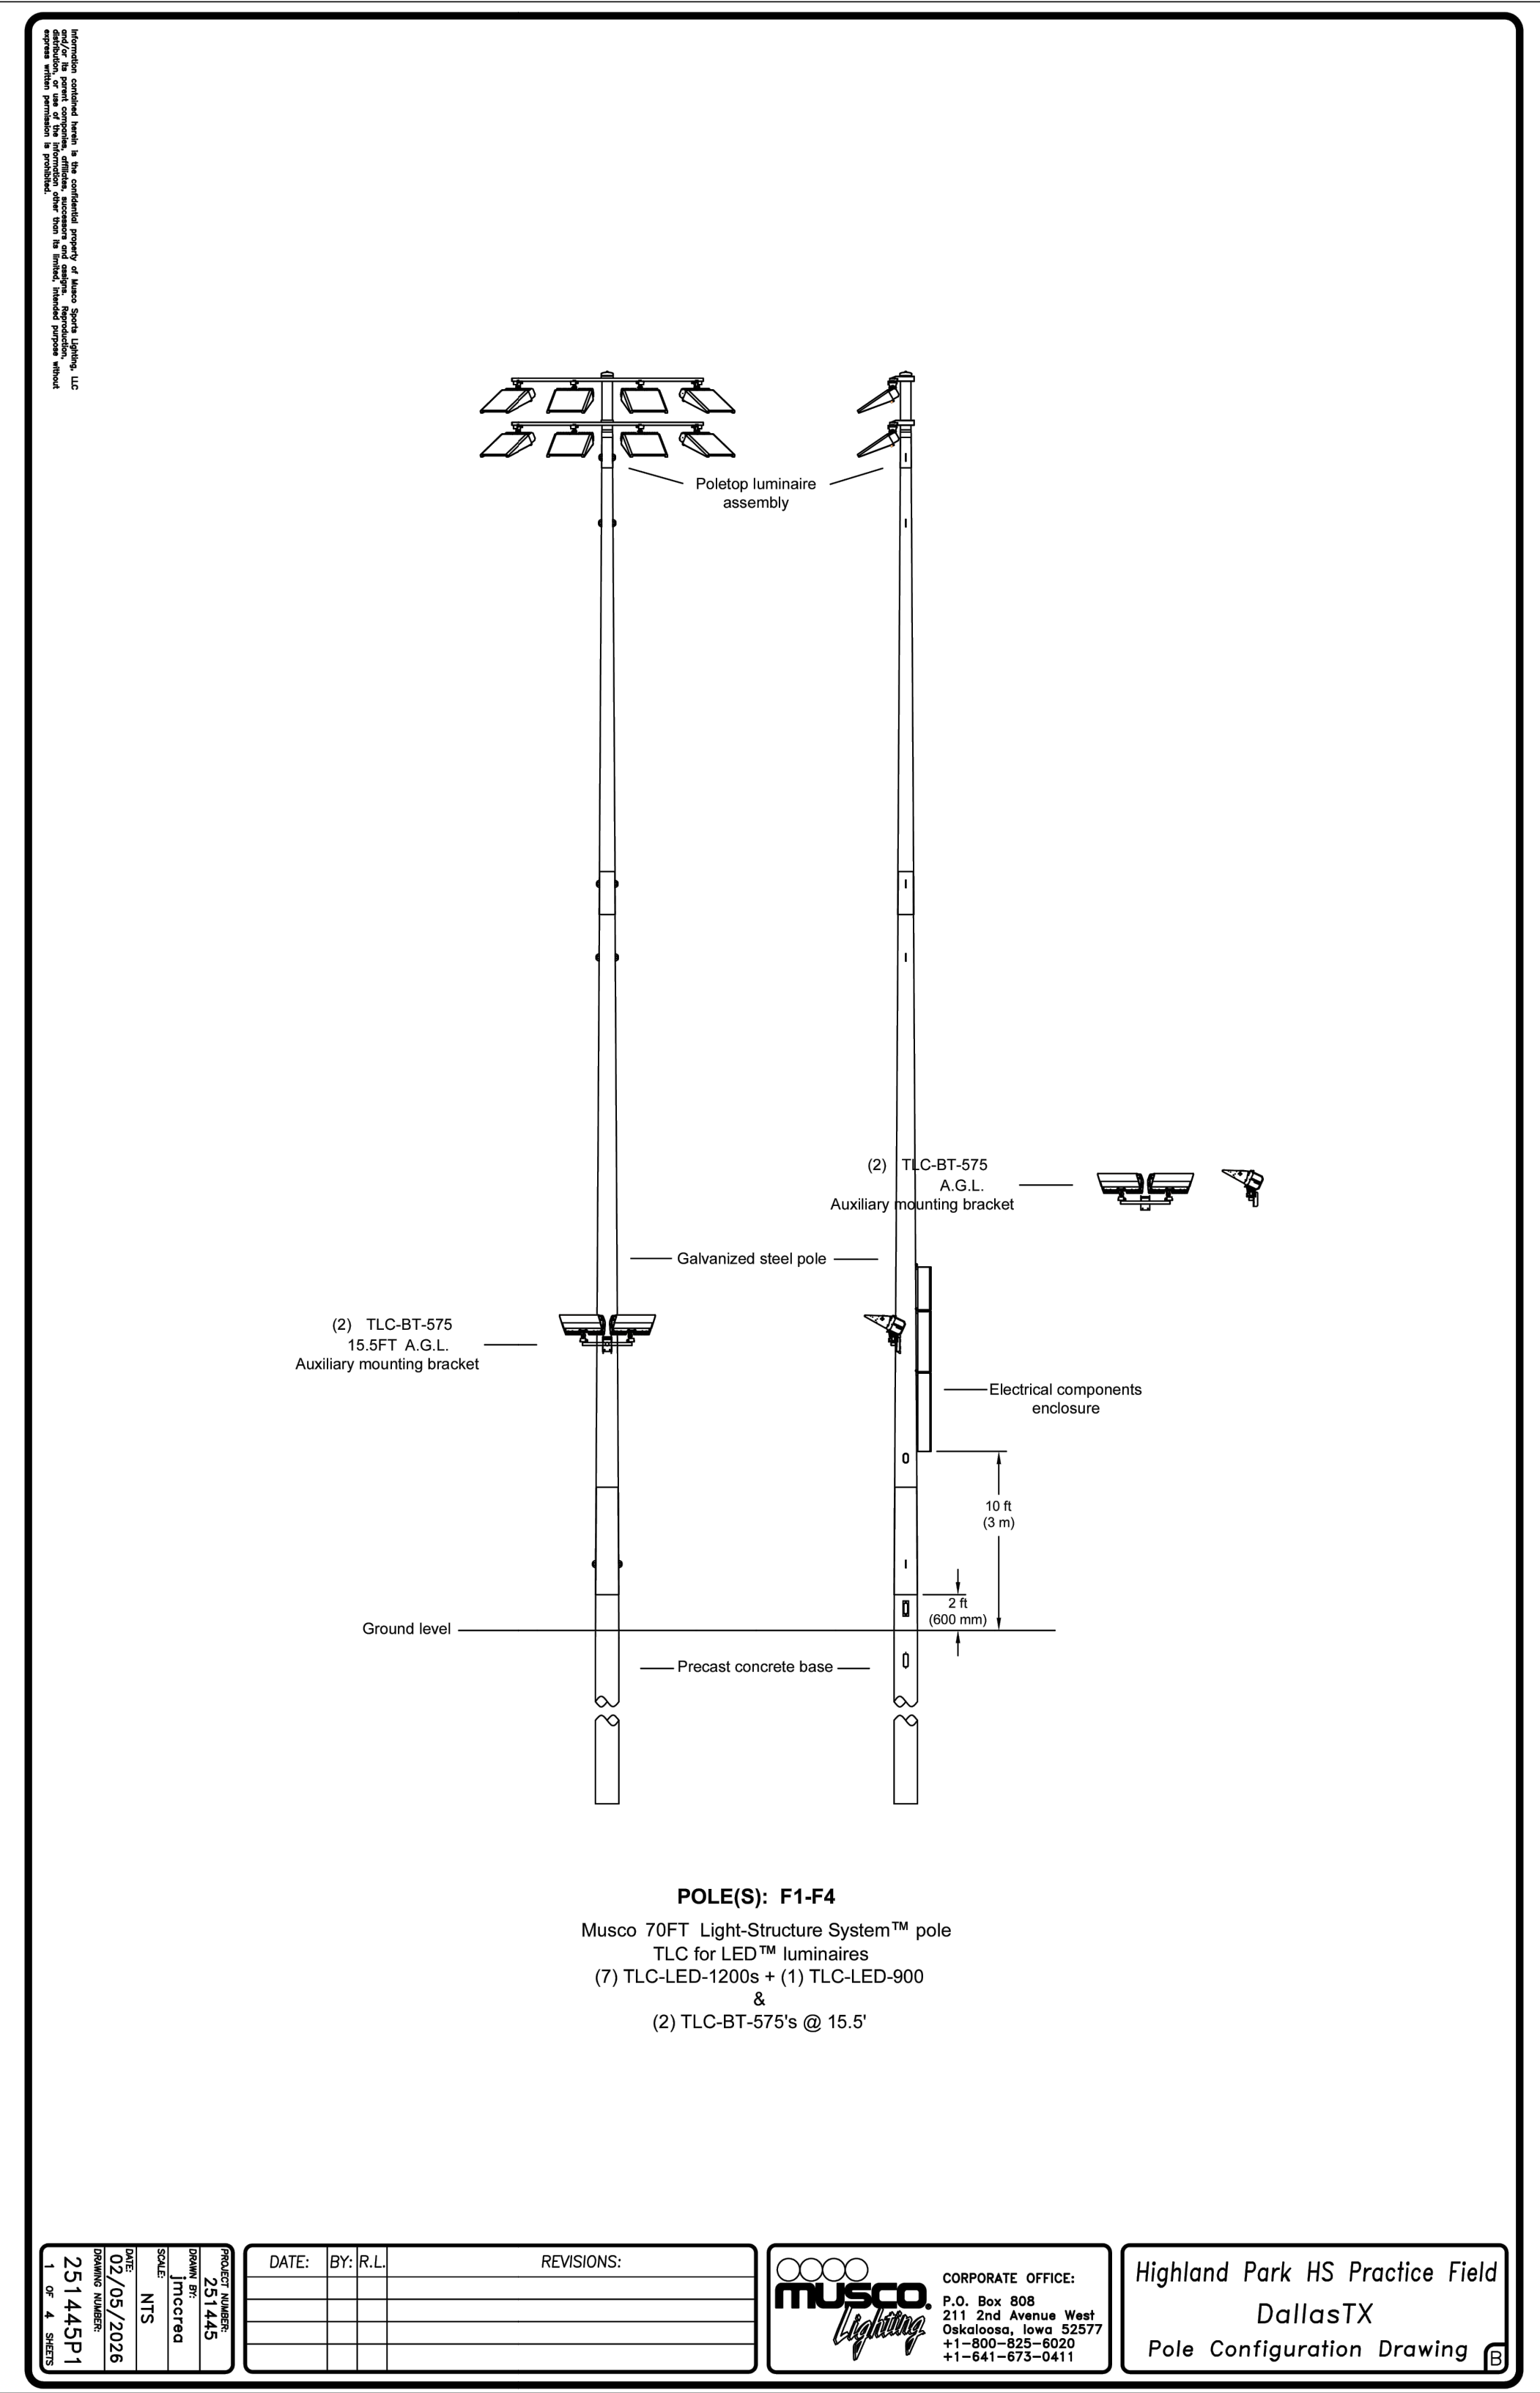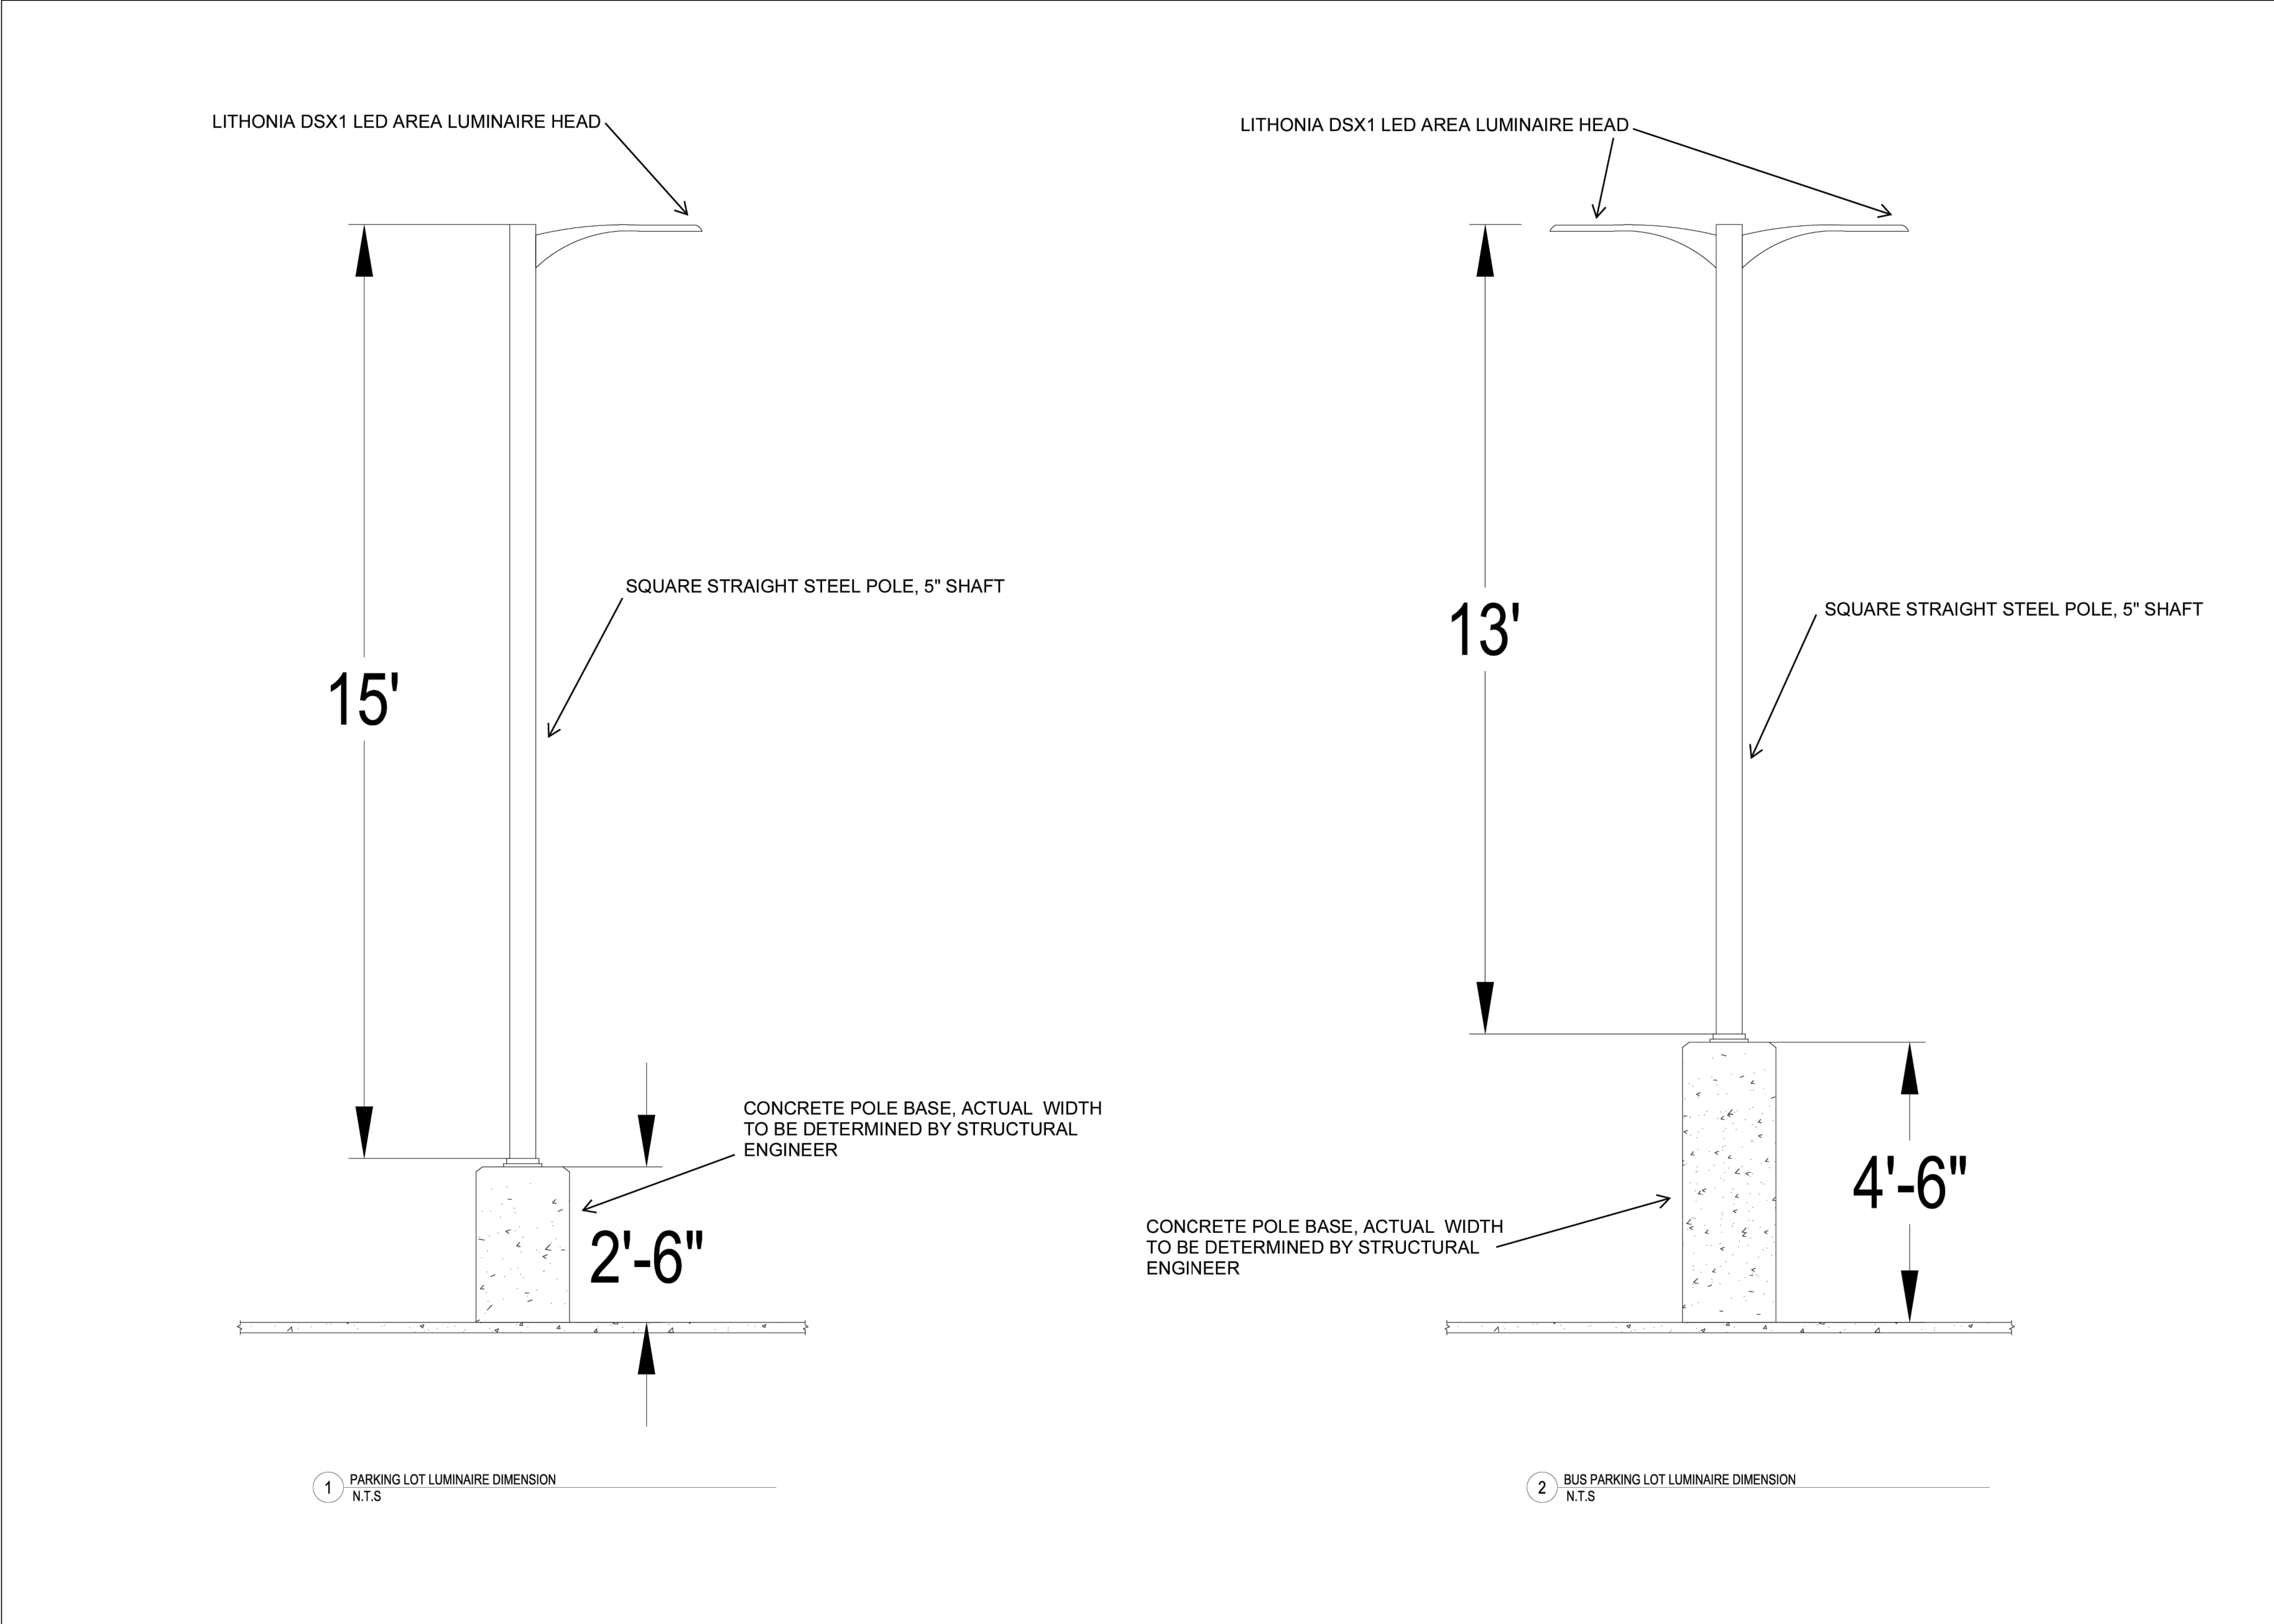

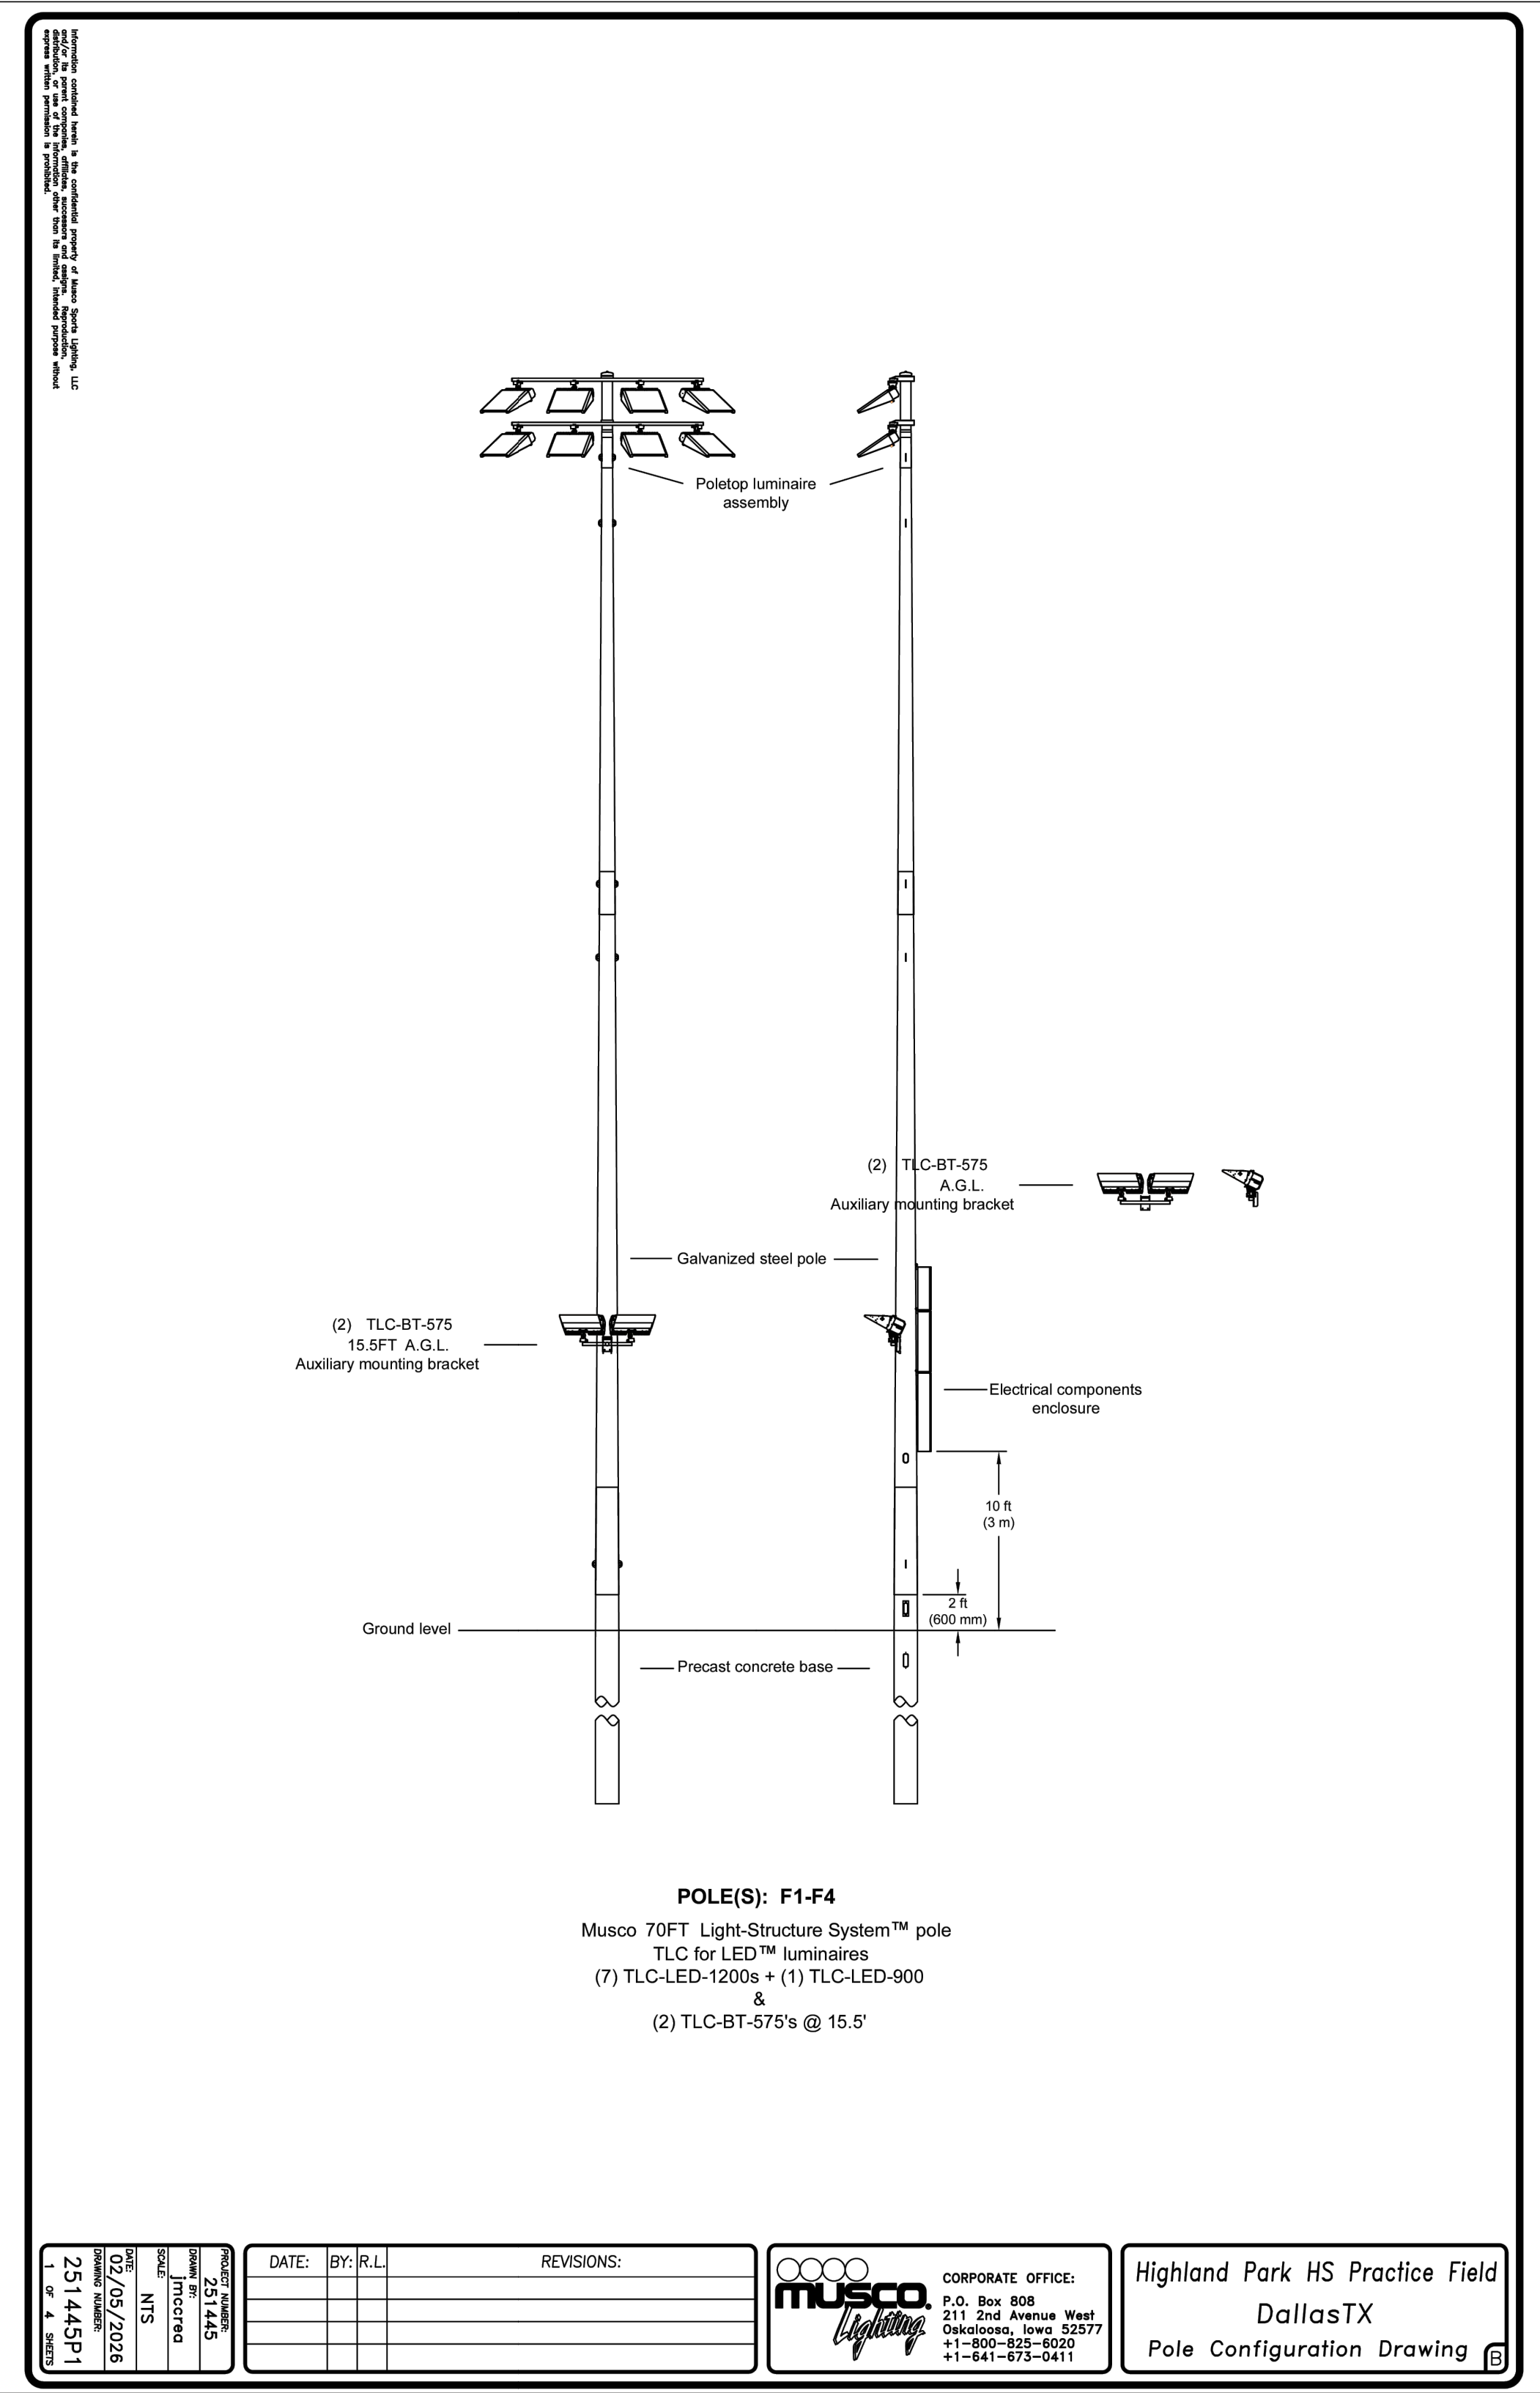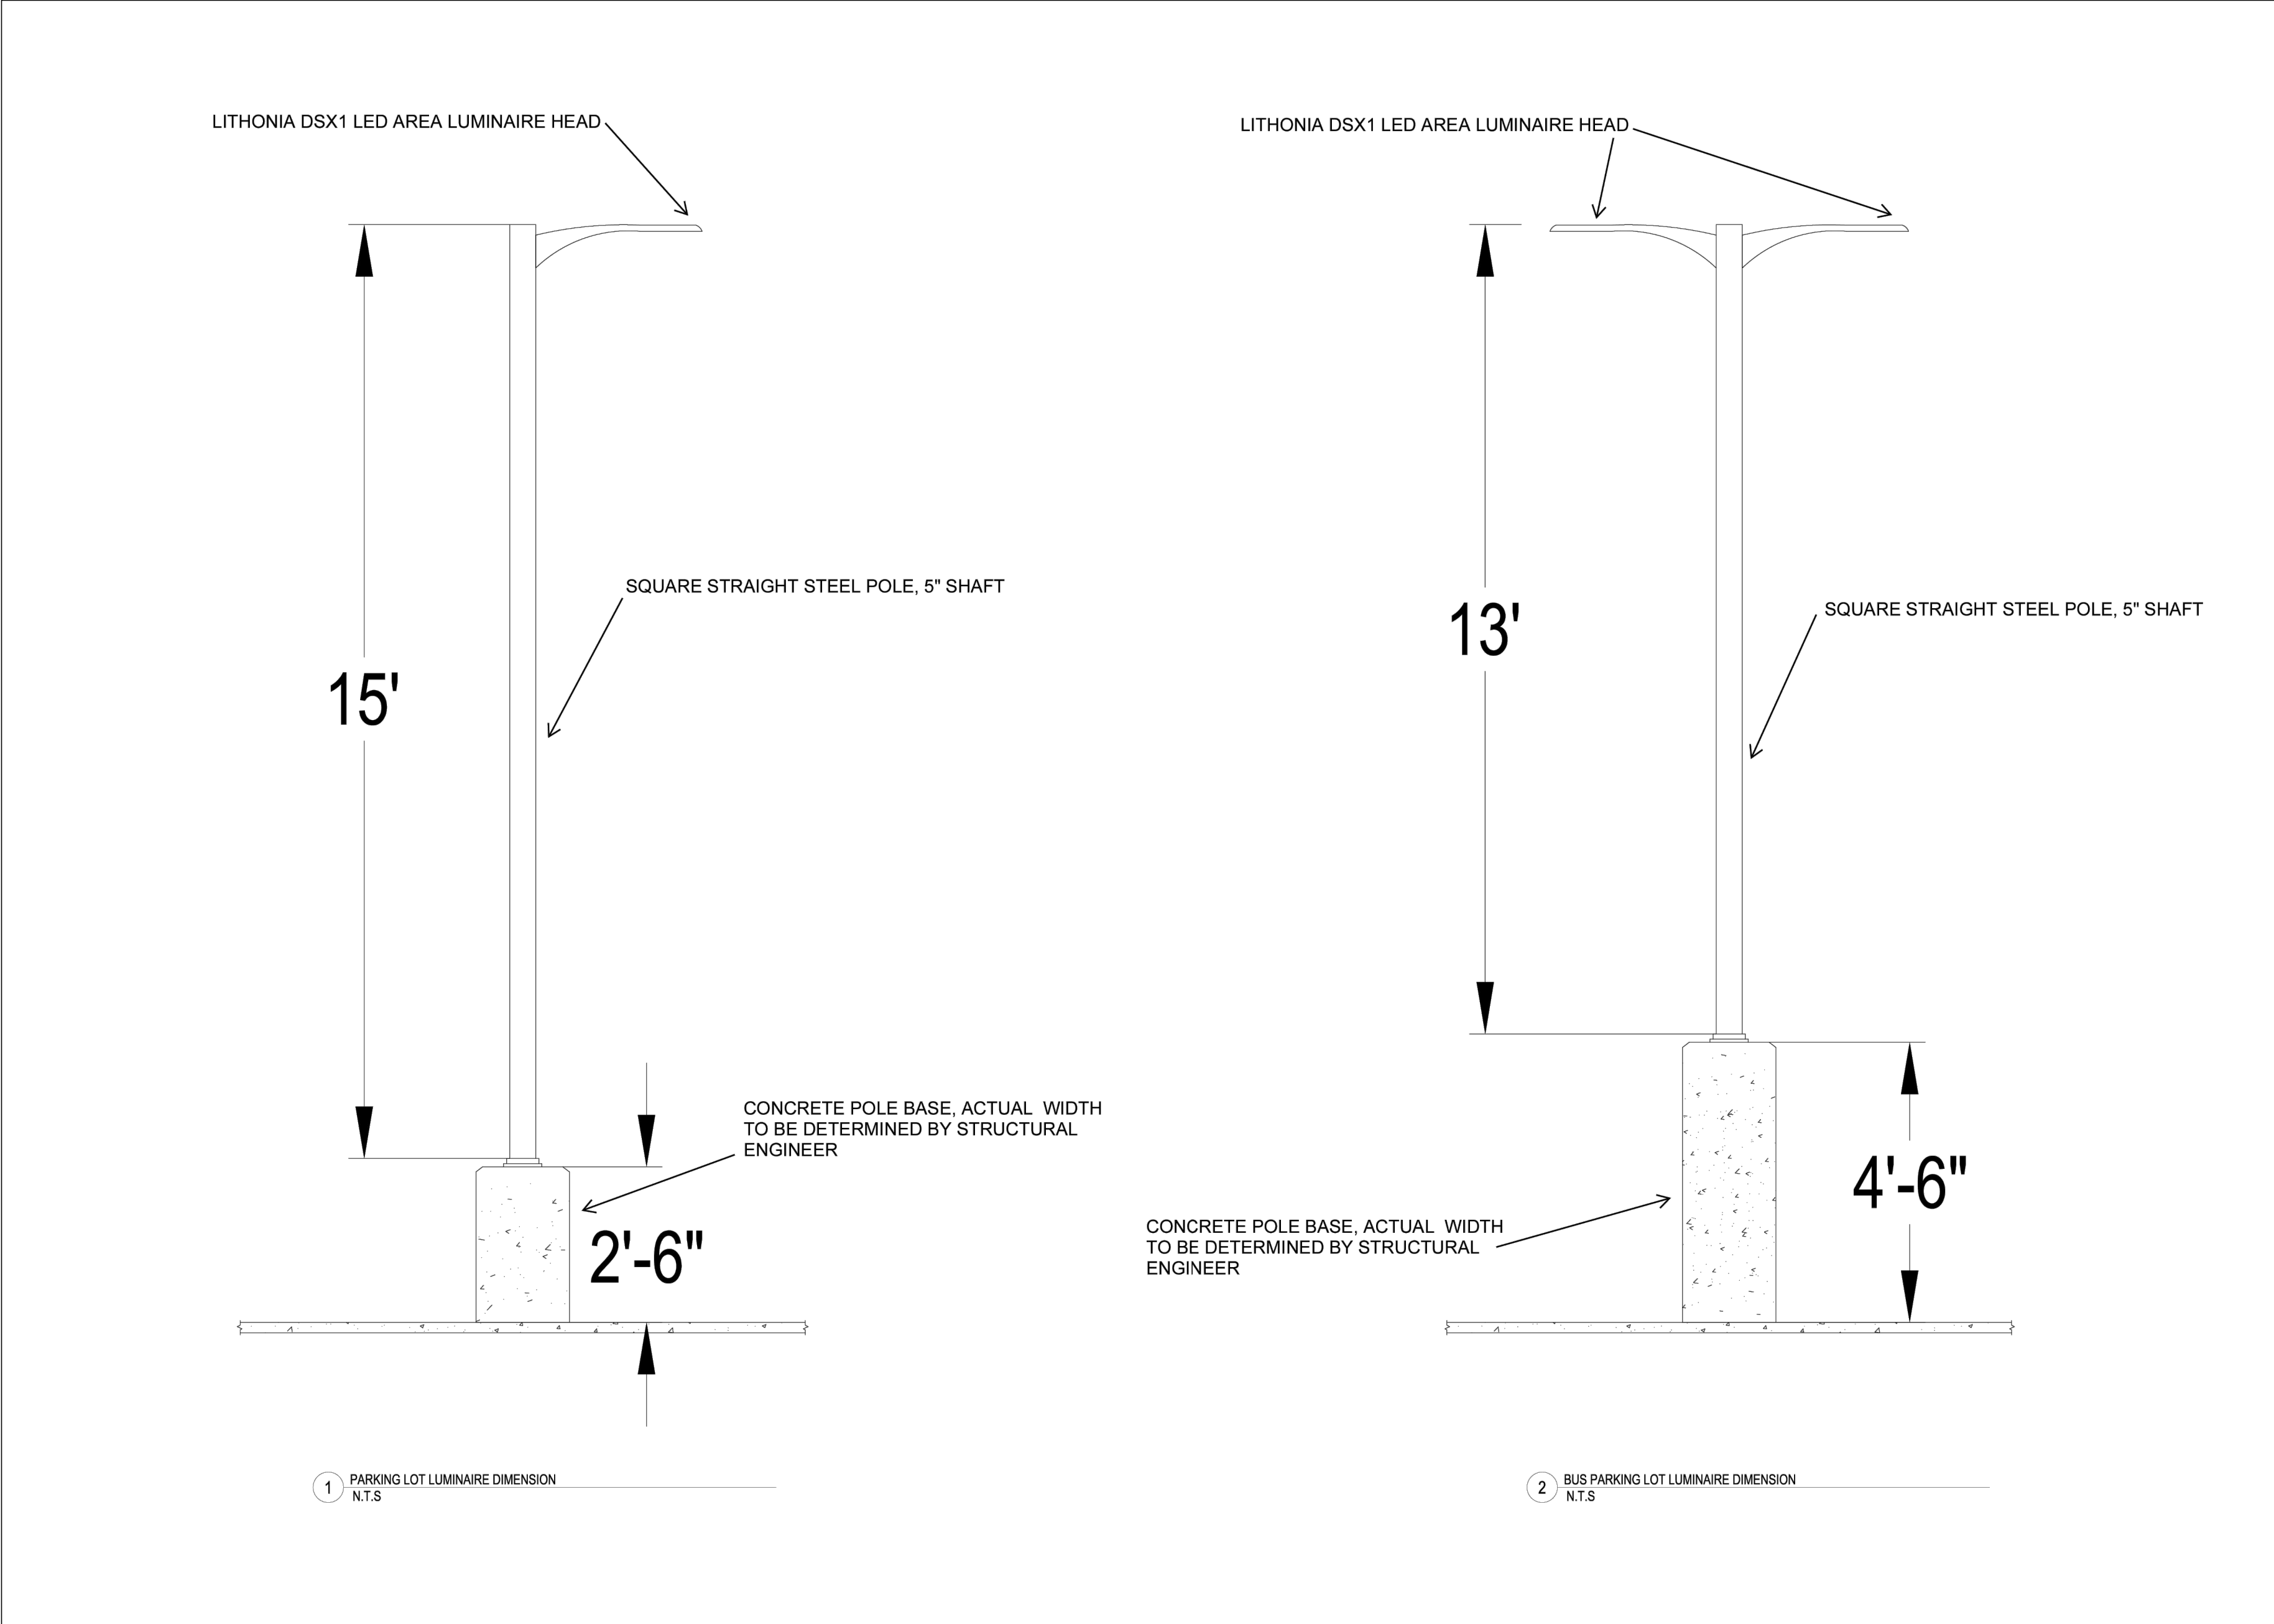

ARCHITECT

VLK Architects, Inc.
5801 Tennyson Pkwy., Suite 100
Plano, Texas 75024
Main Phone: 972.265.1885
www.vlkarchitects.com

CIVIL ENGINEER

Glenn Engineering
TBPE Firm F-303
HUB #1752575163300
4500 Fuller Drive, Suite 220
Irving, Texas 75038
Main Phone: 972.717.5151
www.glennengineering.com


HIGHLAND PARK HIGH SCHOOL CAMPUS

THIS DOCUMENT IS RELEASED
FOR THE PURPOSE OF INTERIM
REVIEW UNDER THE AUTHORITY
OF MIKE GLENN, P.E. 35059,
ON February 6, 2026
IT IS NOT TO BE USED FOR
CONSTRUCTION PURPOSES


REVISIONS	
Revision No.	
Director	CMA
Approver	CMA
Designer	GEC
Designer	GEC
Proj. Arch.	
Checker	RMR
PROJECT NO.	

SHEET TITLE	
SITE DETAILS - LIGHTING	
SHEET NO.	


C03.22

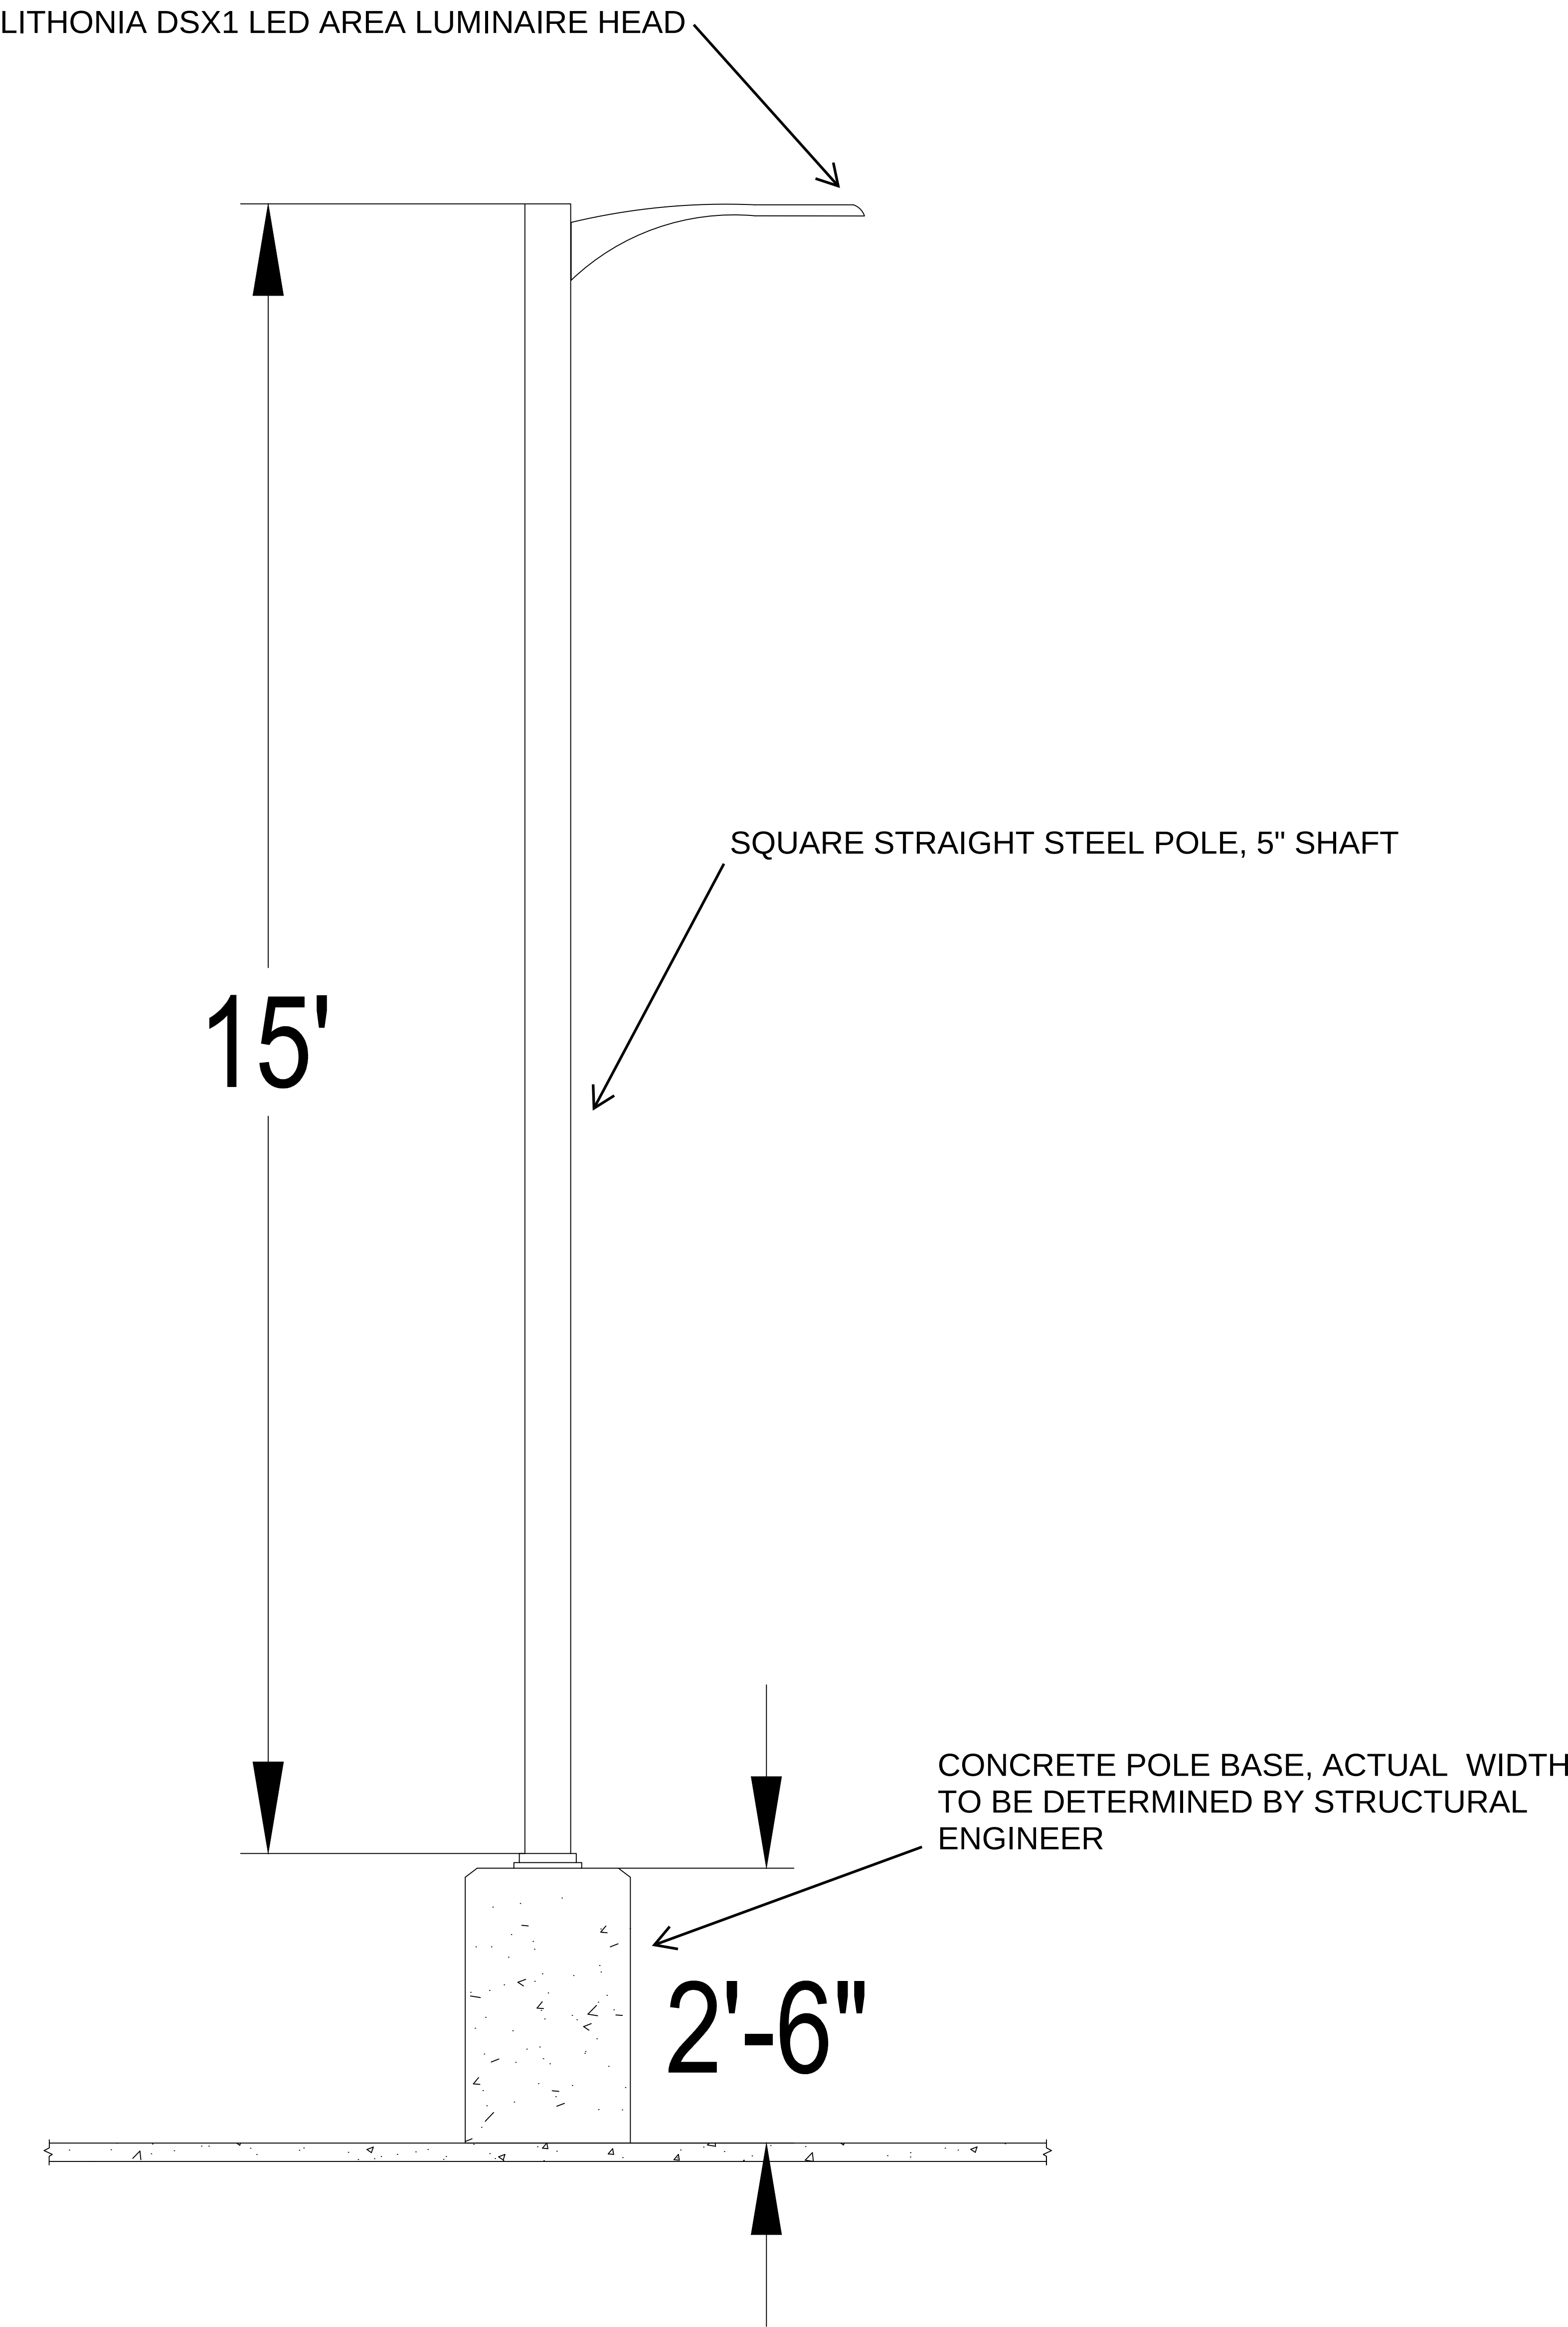


1 PARKING LOT LUMINAIRE DIMENSION
N.T.S

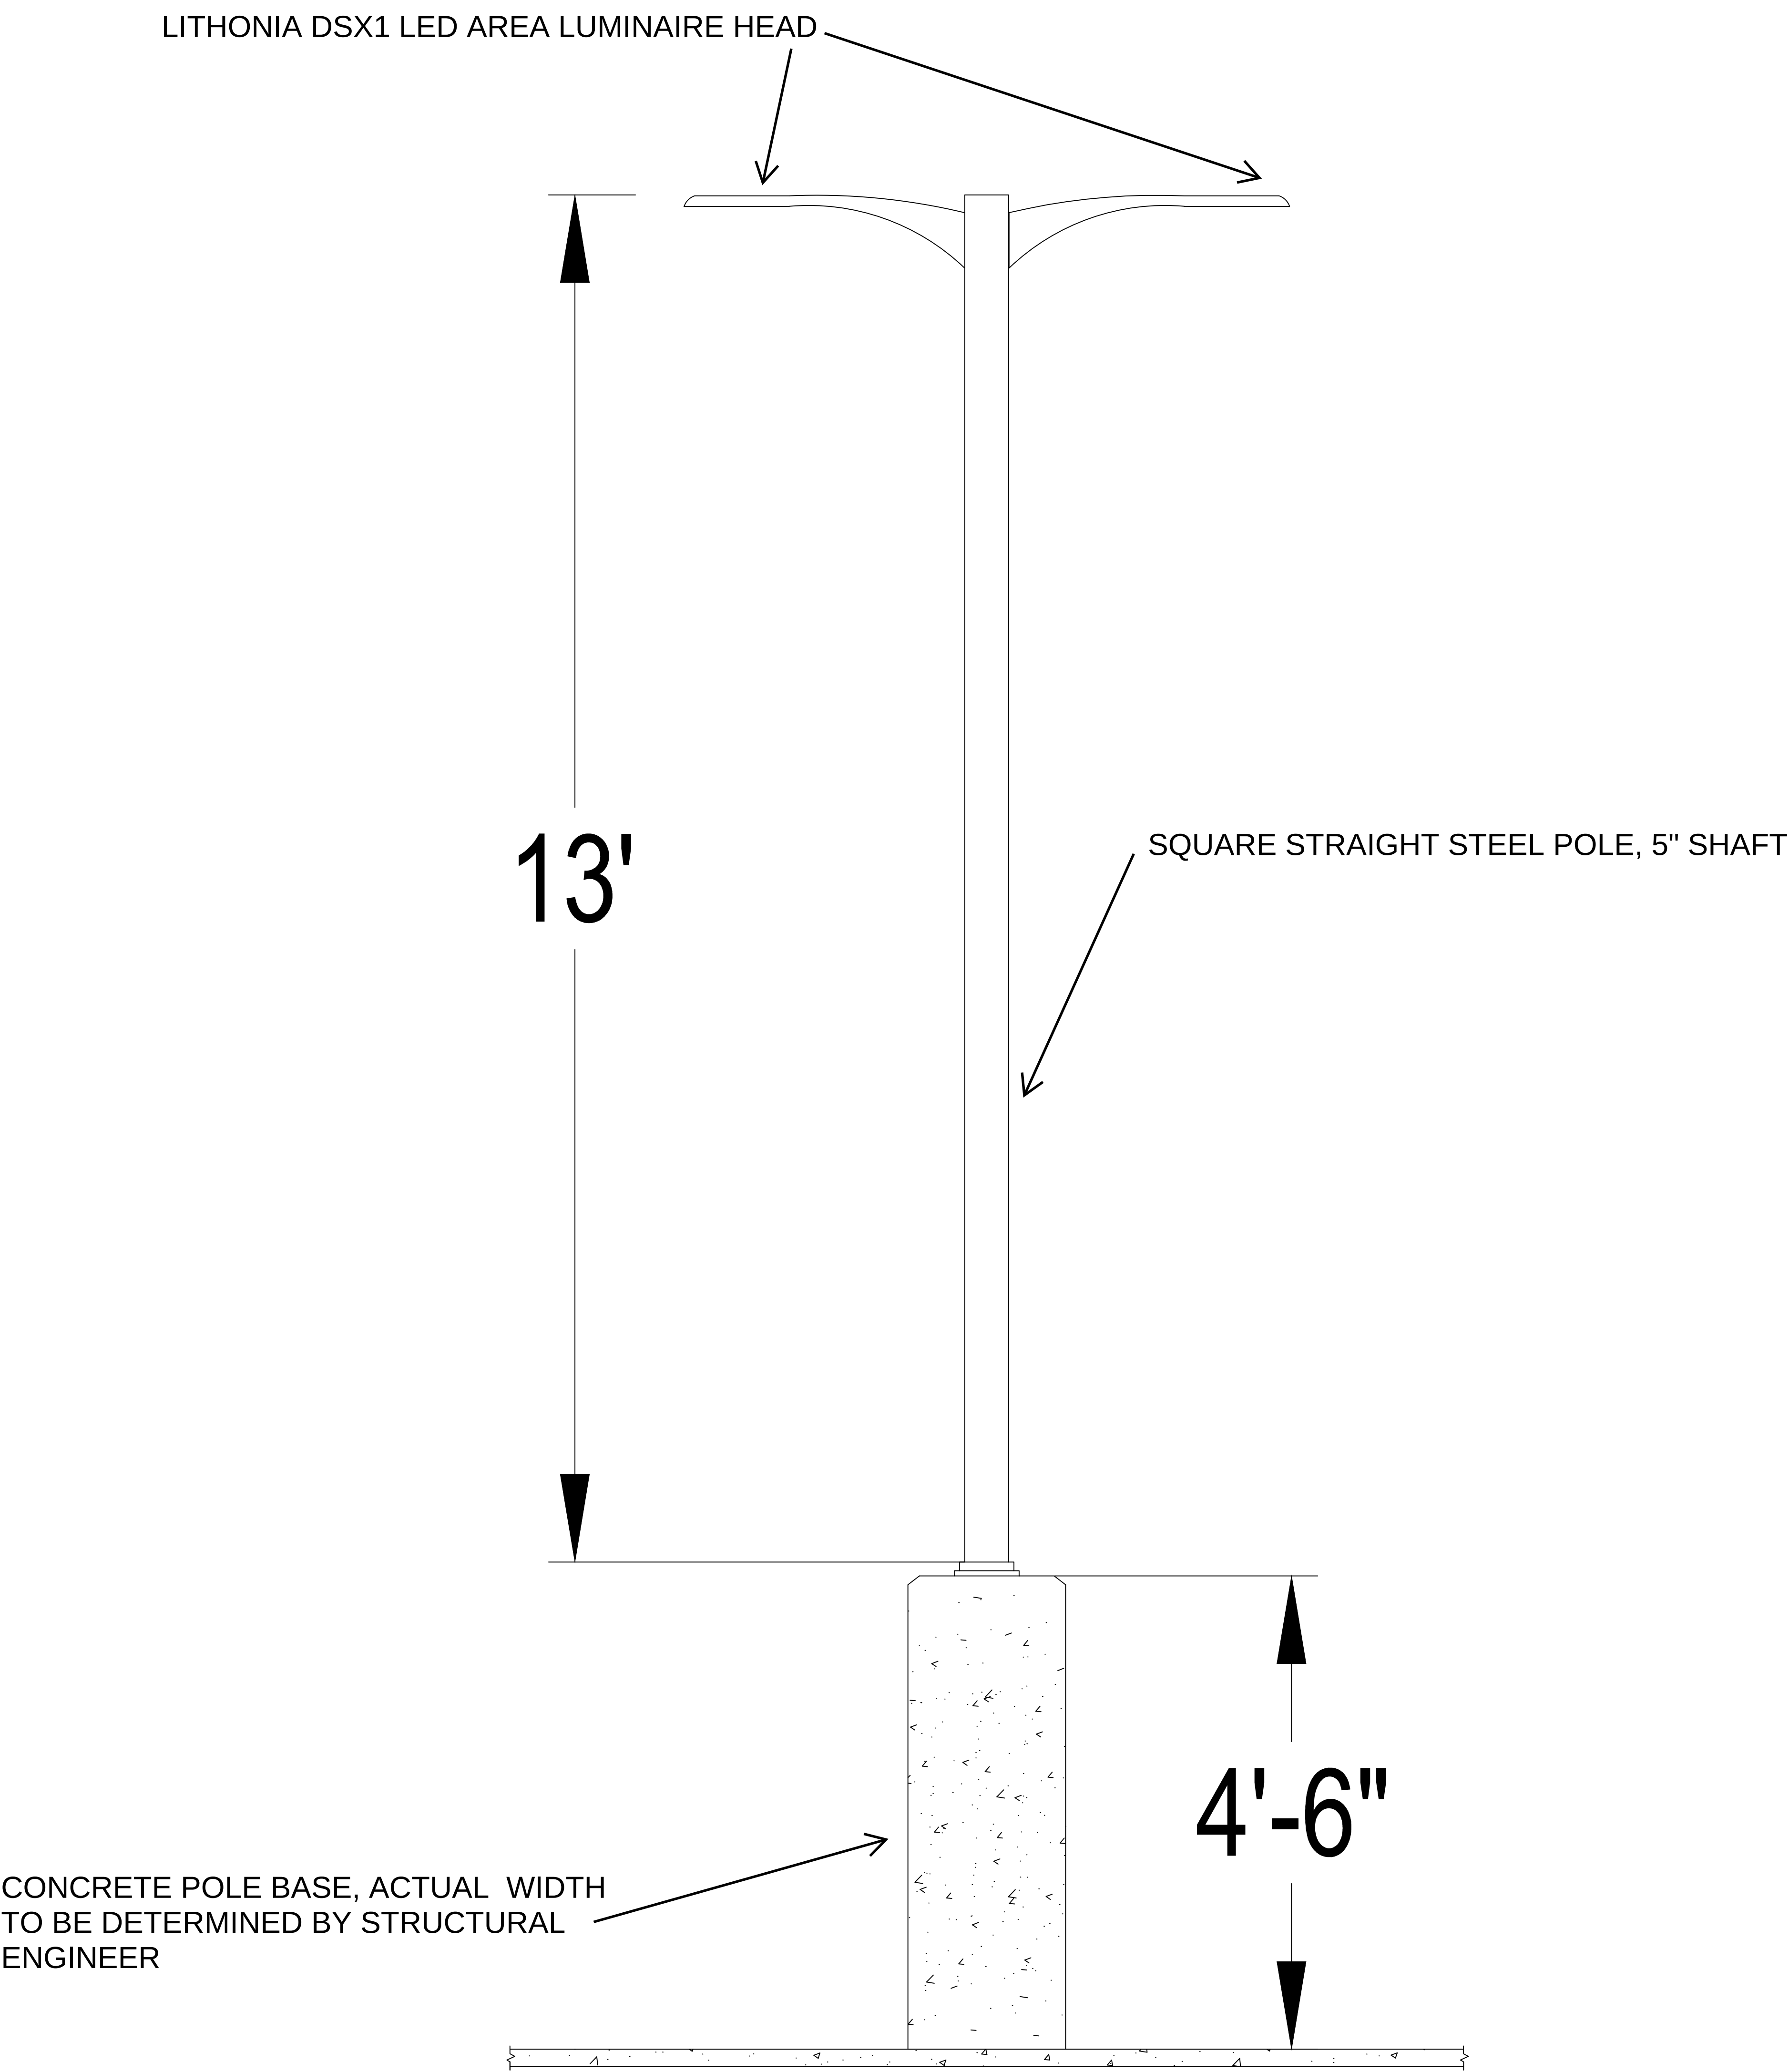

2 BUS PARKING LOT LUMINAIRE DIMENSION
N.T.S

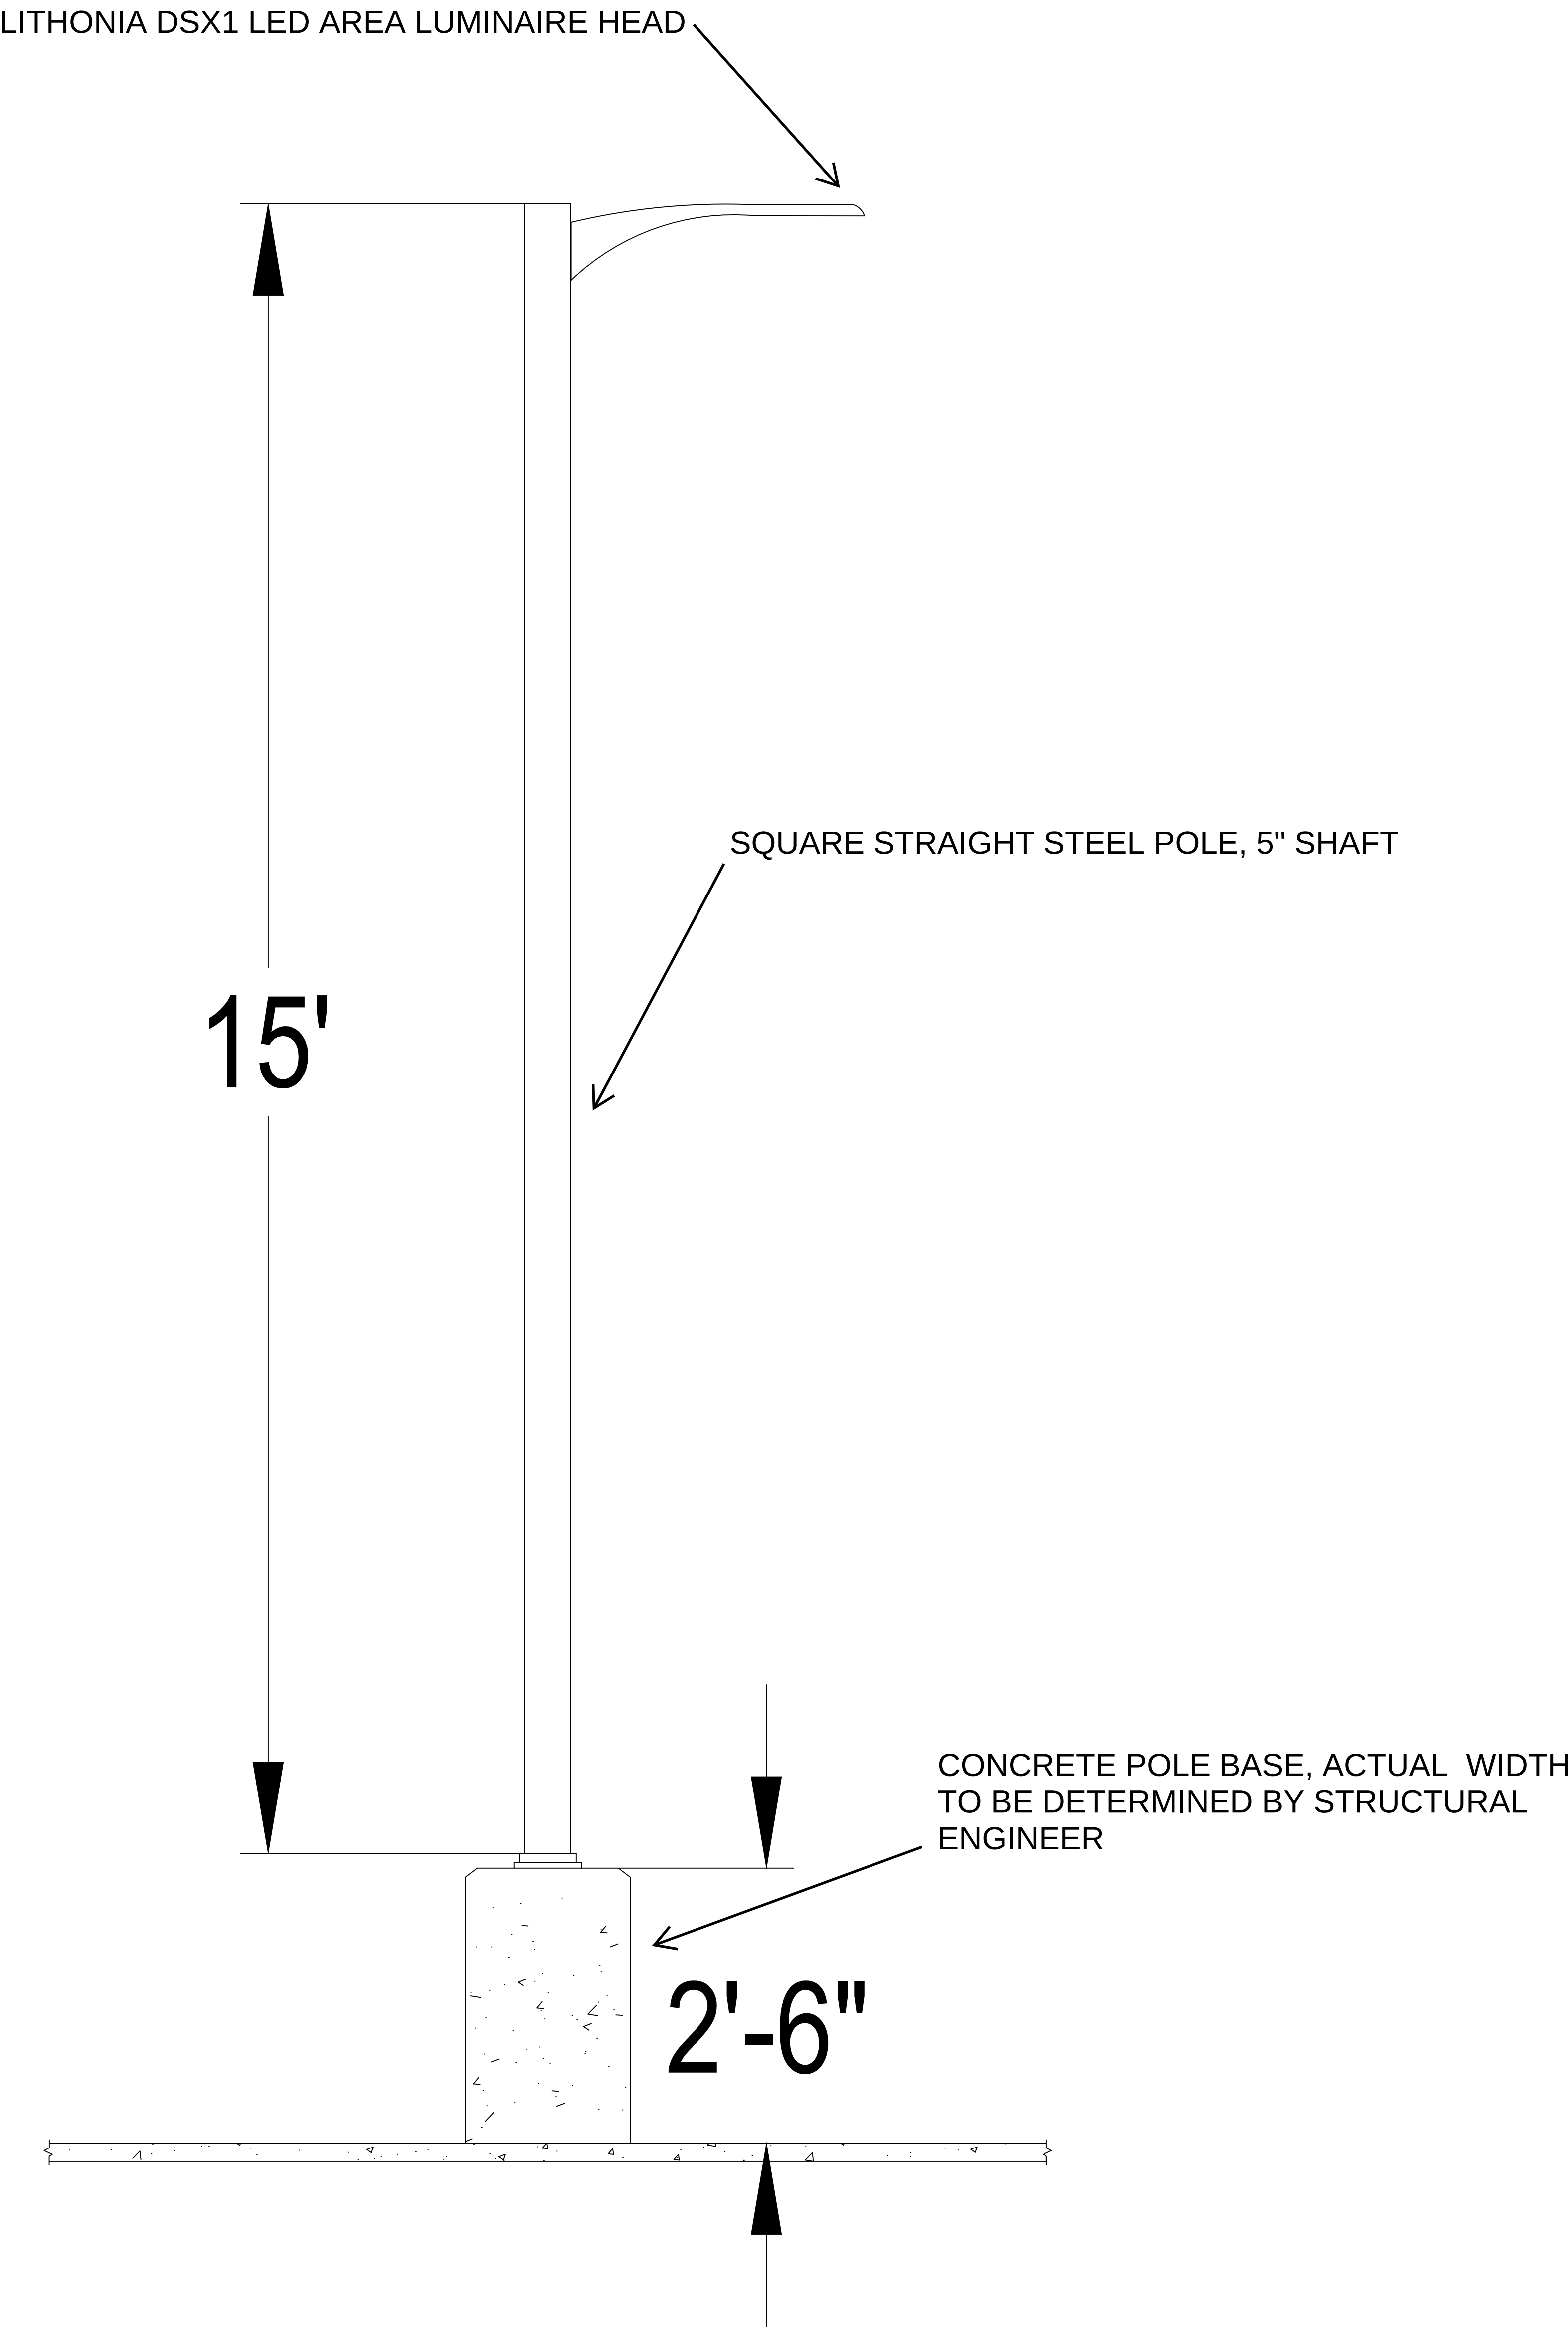

1 PARKING LOT LUMINAIRE DIMENSION
N.T.S

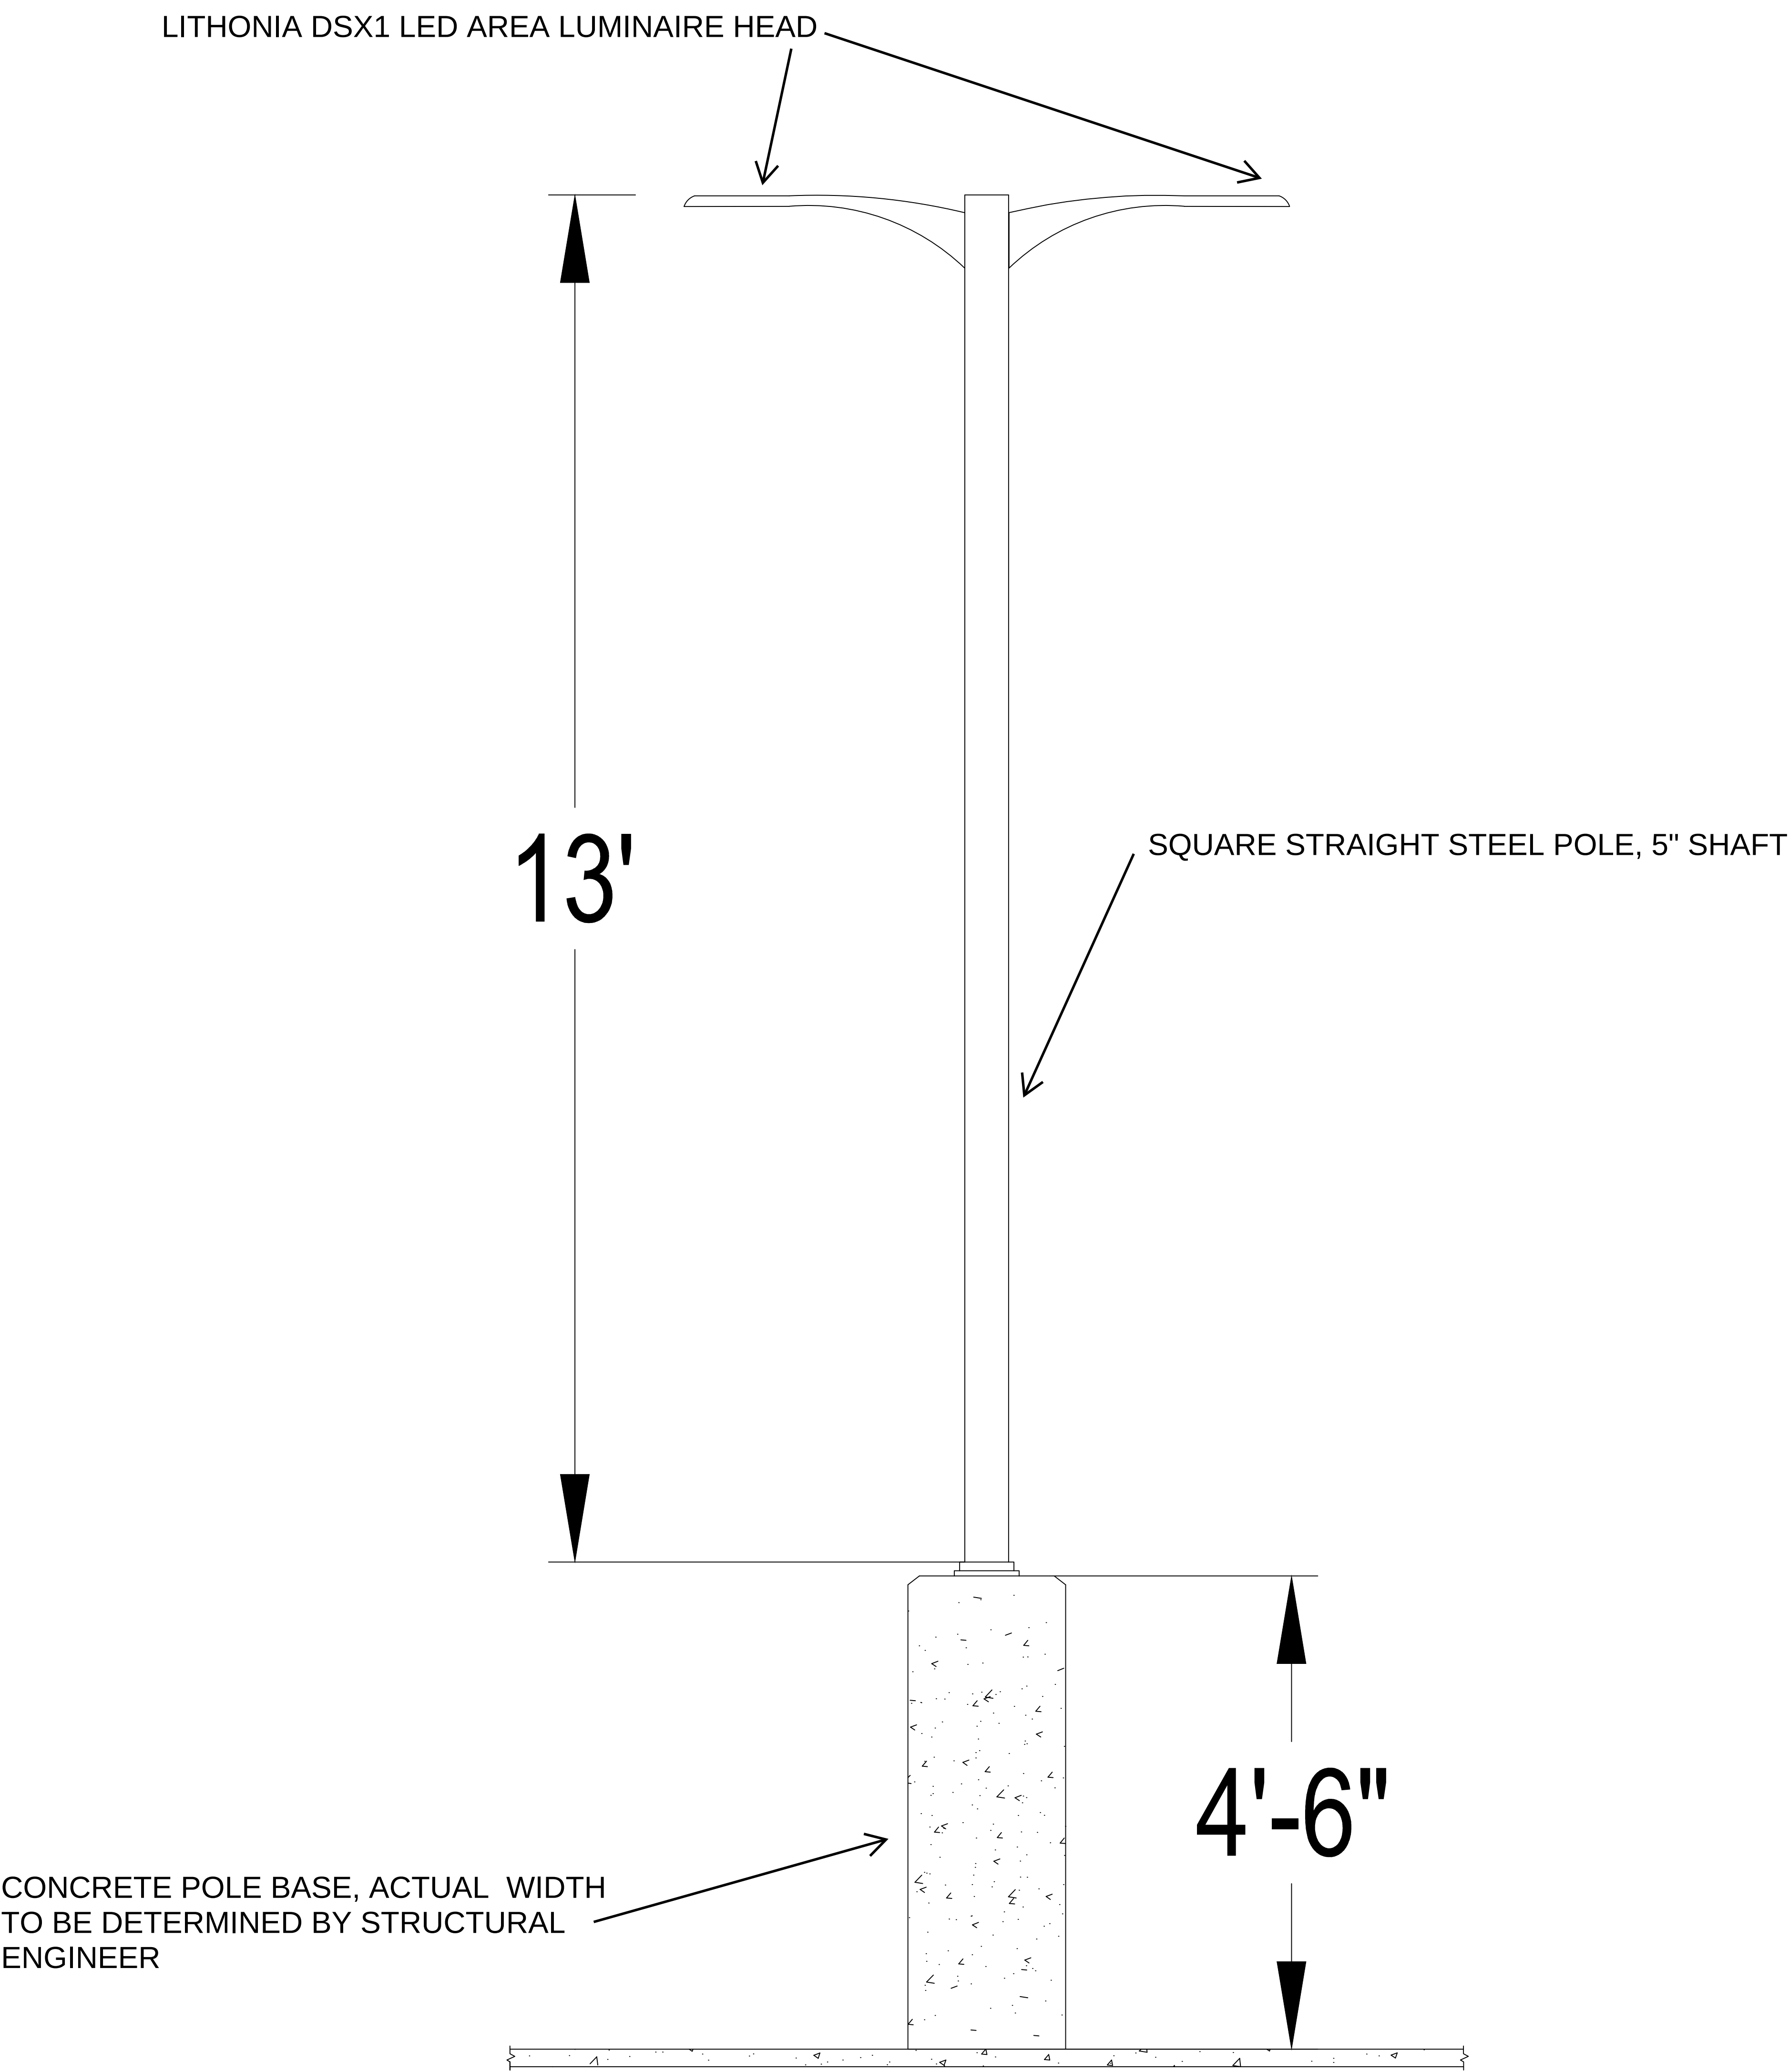

2 BUS PARKING LOT LUMINAIRE DIMENSION
N.T.S

PHOTOMETRIC SITE PLAN GENERAL NOTES

1. THESE PLANS ARE ACCURATE AND DESIGNED IN COMPLIANCE WITH AND MEET THE REQUIREMENTS OF THE **CITY OF xx / TOWN OF xx** SUBMISSION OF PLANS.
2. ALL CALCULATIONS SHOWN ARE AT THE GROUND LEVEL AND ARE MEASURED HORIZONTALLY.
3. LIGHTING CALCULATIONS HAVE BEEN PRODUCED USING AGI32 LIGHTING SOFTWARE BY LIGHTING ANALYSTS, INC.



ARCHITECT

VLK
5801 Tennyson Pkwy, Suite 100
Plano, Texas 75024
Main Phone: 972.265.1885
www.vlkarchitects.com

FOOD SERVICE

JMK
3431 Lakeview Pkwy Ste 205
Rowlett, TX 75088
Main Phone: 214.227.2481
www.jmkda.net

M.E.P. ENGINEER

EMA ENGINEERING
328 S Broadway Ave
Tyler, Texas 75702
Main Phone: 903.581.2677
www.emaengineer.com

CONSTRUCTION MANAGER

LEE LEWIS CONSTRUCTION
17177 Preston Rd #160,
Dallas, TX 75248
Main Phone: 972.818.0700
www.leelewis.com

ROOFING

DRYTEC
8750 N Central Expy #75231
Dallas, TX 75231
Main Phone: 214.363.2192
www.drytecmc.com

100% Construction
Documents Review

REVIEW ONLY

NOT FOR REGULATORY
APPROVAL, PERMITTING,
OR CONSTRUCTION

Engineer: **James M. Tate III**

License State: **TX** License No.: **102427**

Date: **2/2/2026 4:03:32 PM**

Project Issued: 03/14/2025

REVISIONS

Revision No. Revision Date

Director MN

Proj. Arch. HA

PROJECT NO.

25-0004.00

SHEET TITLE

PHOTOMETRIC SITE PLAN

SHEET NO.

ES1.2


COPYRIGHT © 2025 VLK ARCHITECTS

HIGHLAND PARK ISD
4220 Emerson Ave, Dallas, TX 75205

HIGHLAND PARK HIGH SCHOOL RENOVATION

LOVERS LANE


(A 62.0 FOOT WIDTH RIGHT-OF-WAY)

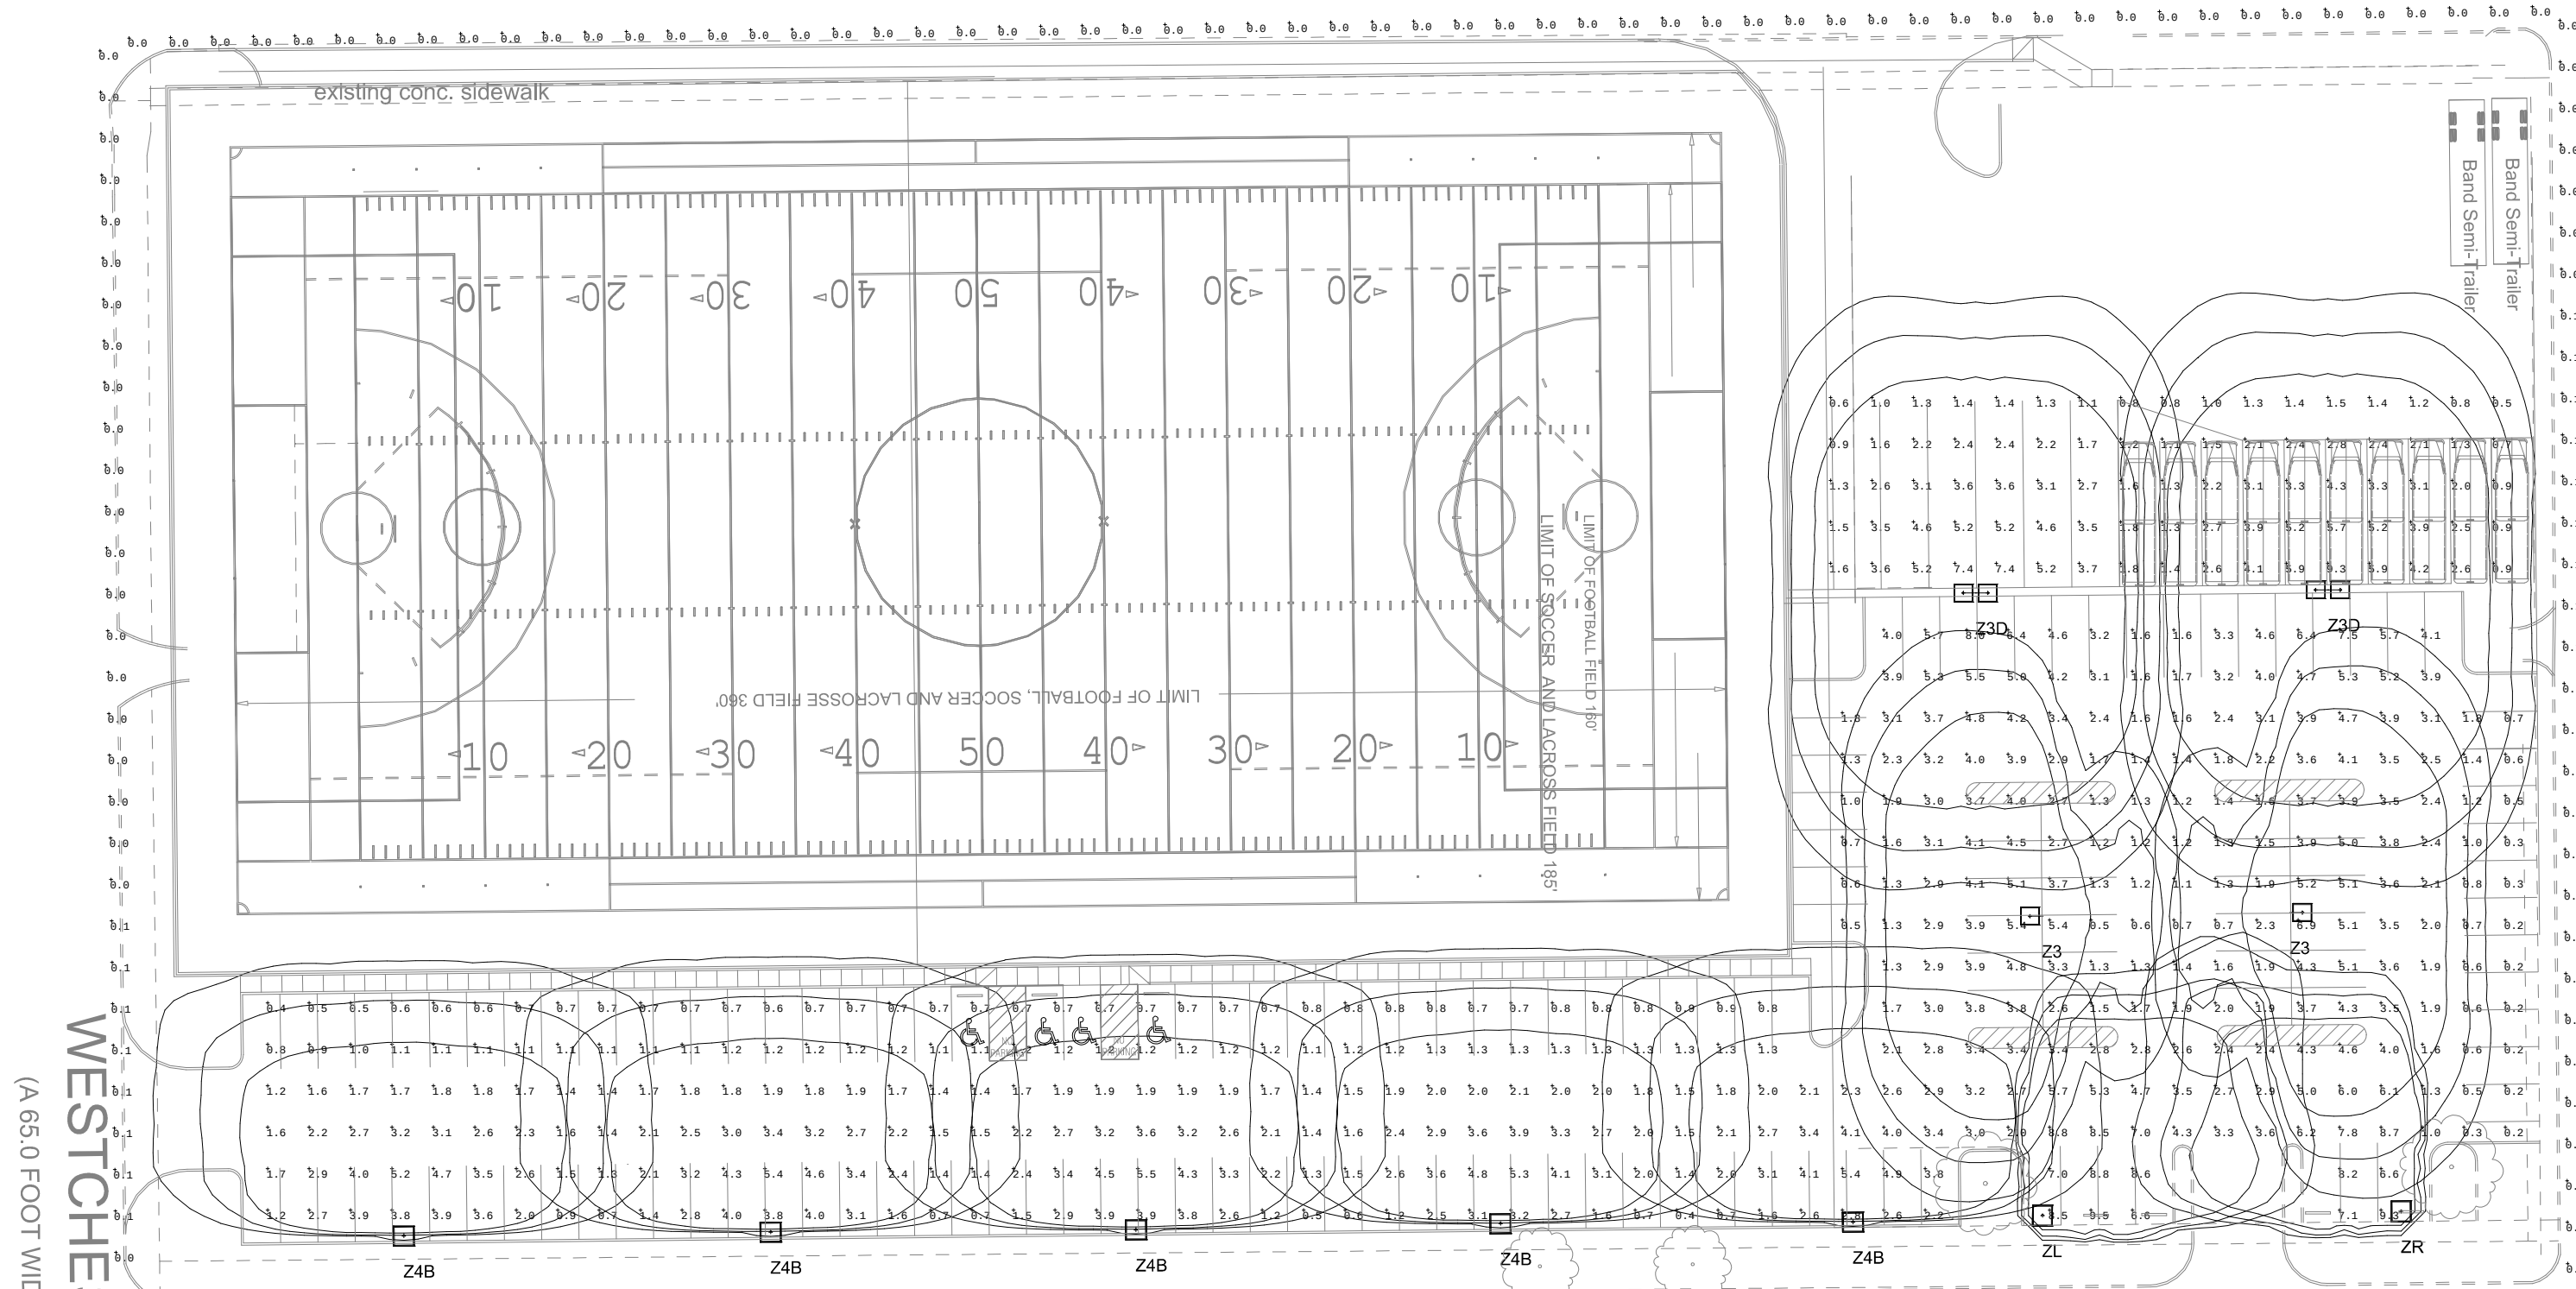

HYER STREET

(A 45.0 FOOT WIDTH RIGHT-OF-WAY)

Calculation Summary							
Category	CalcType	Units	Avg	Max	Min	Avg/Min	Max/Min
Light							
Bus Parking	Footcandle	FC	2.89	9.3	0.5	5.58	38.66
Grassmere Dr Parking Lot	Footcandle	FC	3.86	12.1	0.5	6.16	24.26
Hyer St Parking Lot	Footcandle	FC	2.88	9.5	0.2	37.88	47.88
Property Line	Footcandle	FC	0.87	6.1	0.0	N/A	N/A
Property Line West View	Footcandle	FC	0.89	6.1	0.0	N/A	N/A
Property Line South Parking Lot	Footcandle	FC	0.87	6.1	0.0	N/A	N/A

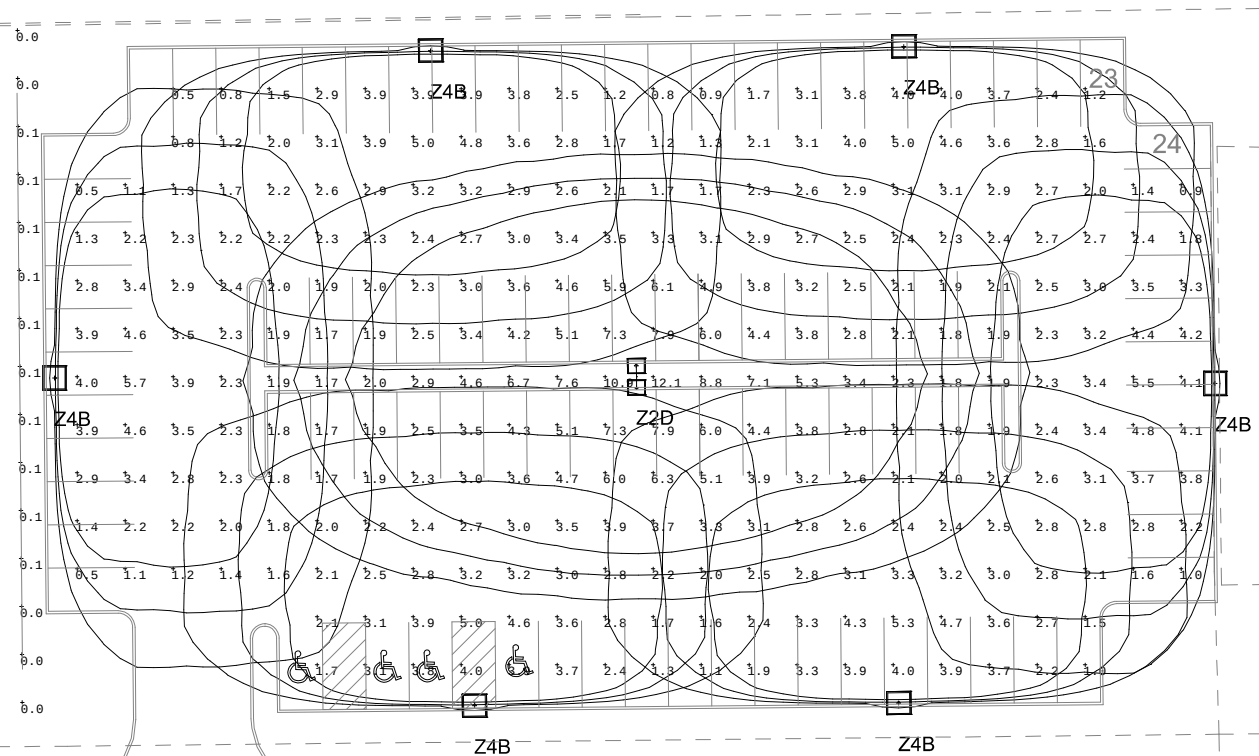

GRASSMERE LANE

(A 45.0 FOOT WIDTH RIGHT-OF-WAY)

1 PHOTOMETRIC SITE PLAN
1"=40'-0"

EMA Engineering & Consulting, Inc.
Tyler | Austin | Houston | El Paso
DFW | San Antonio | Shreveport
Texas Firm Registration No. F-893
Louisiana Firm Registration No. EF-5818
www.EMAengineer.com

SUBMISSION OF BID WILL BE CONSIDERED ACKNOWLEDGMENT THAT THE CONTRACTOR HAS VISITED THE SITE AND HAS VERIFIED ALL EXISTING JOB CONDITIONS AND INCLUDED ANY NECESSARY MODIFICATION TO EXISTING AND NEW WORK REQUIRED FOR INSTALLATION OF A COMPLETE AND WORKING SYSTEM.




D-Series Size 1 LED Area Luminaire



d#series

Specifications

EPA:	0.69 ft ² (0.06 m ²)
Length:	32.71" (83.1 cm)
Width:	14.26" (36.2 cm)
Height H1:	7.88" (20.0 cm)
Height H2:	2.73" (6.9 cm)
Weight:	34 lbs (15.4 kg)

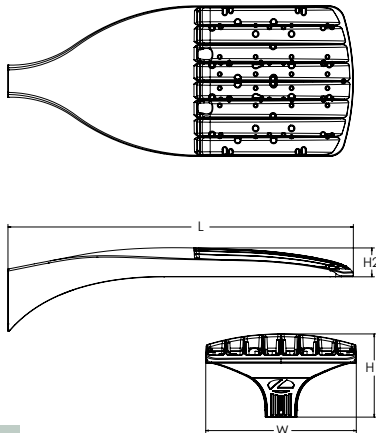

Design Select options indicated by this color background.

Catalog
Number

Notes

Type

Hit the Tab key or mouse over the page to see all interactive elements.

Introduction

The modern styling of the D-Series features a highly refined aesthetic that blends seamlessly with its environment. The D-Series offers the benefits of the latest in LED technology into a high performance, high efficacy, long-life luminaire.

The photometric performance results in sites with excellent uniformity, greater pole spacing and lower power density. D-Series outstanding photometry aids in reducing the number of poles required in area lighting applications with typical energy savings of 65% and expected service life of over 100,000 hours.



Items marked by a shaded background qualify for the Design Select program and ship in 15 days or less. To learn more about Design Select, visit www.acuitybrands.com/designselect.
*See ordering tree for details

Ordering Information

EXAMPLE: DSX1 LED P7 40K 70CRI T3M MVOLT SPA NLTAIR2 PIRHN DDBXD

DSX1 LED						
Series	LEDs	Color temperature ²	Color Rendering Index ²	Distribution	Voltage	Mounting
DSX1 LED	Forward optics	(this section 70CRI only)		AFR Automotive front row	TSM Type V medium	MVOLT (120V-277V) ⁴
	P1 P6	30K 3000K	70CRI	T1S Type I short	TSLG Type V low glare	HVOLT (347V-480V) ^{5,6}
	P2 P7	40K 4000K	70CRI	T2M Type II medium	T5W Type V wide	XVOLT (277V - 480V) ^{7,8}
	P3 P8	50K 5000K	70CRI	T3M Type III medium	BLC3 Type III backlight control ³	120 ^{16,26}
	P4 P9			T3LG Type III low glare ³	BLC4 Type IV backlight control ³	208 ^{16,26}
	P5	27K 2700K	80CRI	T4M Type IV medium		240 ^{16,26}
	Rotated optics	30K 3000K	80CRI	T4LG Type IV low glare ³	LCCO Left corner cutoff ³	277 ^{16,26}
	P10 ¹ P12 ¹	35K 3500K	80CRI	TFTM Forward throw medium	RCCO Right corner cutoff ³	347 ^{16,26}
	P11 ¹ P13 ¹	40K 4000K	80CRI			480 ^{16,26}
		50K 5000K	80CRI			
						Shipped included
						SPA Square pole mounting (#8 drilling)
						RPA Round pole mounting (#8 drilling)
						SPA5 Square pole mounting #5 drilling ⁹
						RPA5 Round pole mounting #5 drilling ⁹
						SPA8N Square narrow pole mounting #8 drilling
						WBA Wall bracket ¹⁰
						MA Mast arm adapter (mounts on 2 3/8" OD horizontal tenon)

Control options	Other options	Finish (required)
Shipped installed	Shipped installed	DDBXD Dark Bronze
NLTAIR2 PIRHN nLight AIR gen 2 enabled with bi-level motion / ambient sensor, 8-40' mounting height, ambient sensor enabled at 2fc. ^{11,12,20,21}	SPD20KV 20KV surge protection	DBLXD Black
PIR High/low, motion/ambient sensor, 8-40' mounting height, ambient sensor enabled at 2fc. ^{11,12,20,21}	HS Houseside shield (black finish standard) ²²	DNAXD Natural Aluminum
PER NEMA twist-lock receptacle only (controls ordered separately) ¹⁴	L90 Left rotated optics ¹	DWHXD White
PER5 Five-pin receptacle only (controls ordered separate) ^{14,21}	R90 Right rotated optics ¹	DDBTXD Textured dark bronze
	CCE Coastal Construction ²³	DBLBXD Textured black
	HA 50°C ambient operation ²⁴	DNATXD Textured natural aluminum
	BAA Buy America(n) Act and/or Build America Buy America Qualified	DWHGXD Textured white
	SF Single fuse (120, 277, 347V) ²⁵	
	DF Double fuse (208, 240, 480V) ²⁶	
	Shipped separately	
	EGSR External Glare Shield (reversible, field install required, matches housing finish)	
	BSDB Bird Spikes (field install required)	



COMMERCIAL OUTDOOR

1 Acuity Way • Decatur, Georgia 30035 • Phone: 1-800-705-SERV (7378) • www.lithonia.com
© 2011-2025 Acuity Brands Lighting, Inc. All rights reserved.

DSX1-LED
Rev. 08/28/25
Page 1 of 10

Ordering Information

Accessories

Ordered and shipped separately.

DLL127F 1.5 JU	Photocell - SSL twist-lock (120-277V) ²⁵
DLL347F 1.5 CUL JU	Photocell - SSL twist-lock (347V) ²⁵
DLL480F 1.5 CUL JU	Photocell - SSL twist-lock (480V) ²⁵
DSHORT SBK	Shorting cap ²⁵
DSX1HS P#	House-side shield (enter package number 1-13 in place of #)
DSXRPA (FINISH)	Round pole adapter (#8 drilling, specify finish)
DSXSPA5 (FINISH)	Square pole adapter #5 drilling (specify finish)
DSXRPA5 (FINISH)	Round pole adapter #5 drilling (specify finish)
DSX1EGSR (FINISH)	External glare shield (specify finish)
DSX1BSDB (FINISH)	Bird spike deterrent bracket (specify finish)


NOTES

- Rotated optics available with packages P10, P11, P12 and P13. Must be combined with option L90 or R90.
- 30K, 40K, and 50K available in 70CRI and 80CRI. 27K and 35K only available with 80CRI. Contact Technical Support for other possible combinations.
- T3LG, T4LG, BLC3, BLC4, LCCO, RCCO not available with option HS.
- MVOLT driver operates on any line voltage from 120-277V (50/60 Hz).
- HVOLT driver operates on any line voltage from 347-480V (50/60 Hz).
- HVOLT not available with package P1 and P10 when combined with option NLTAIR2 PIRHN or option PIR.
- XVOLT operates with any voltage between 277V and 480V (50/60 Hz).
- XVOLT not available in packages P1 or P10. XVOLT not available with P1, P2, P5, P7, P9, P10, P11 and P13 when combined with option NLTAIR2 PIRHN or PIR. XVOLT not available with fusing (SF or DF).
- SPA5 and RPA5 for use with #5 drilling only (Not for use with #8 drilling).
- WBA cannot be combined with Type 5 distributions plus photocell (PER).
- NLTAIR2 and PIRHN must be ordered together. For more information on nLight AIR2 visit this [link](#).
- NLTAIR2 PIRHN not available with other controls including PIR, PER, PER5, PER7, FAO, BL30, BL50, DMG and DS. NLTAIR2 PIRHN not available with P1 and P10 using HVOLT.
- PIR not available with NLTAIR2 PIRHN, PER, PER5, PER7, FAO BL30, BL50, DMG and DS.
- PER/PER5/PER7 not available with NLTAIR2 PIRHN, PIR, BL30, BL50, FAO, DMG and DS. Photocell ordered and shipped as a separate line item from Acuity Brands Controls. See accessories. Shorting Cap included.
- FAO not available with other dimming control options NLTAIR2 PIRHN, PIR, PER5, PER7, BL30, BL50, DMG and DS.
- BL30 and BL50 are not available with NLTAIR2 PIRHN, PIR, PER, PER5, PER7, FAO, DMG and DS. BL30 or BL50 must specify 120 or 277V.
- DMG not available with NLTAIR2 PIRHN, PIR, PER, PER5, PER7, BL30, BL50, FAO and DS.
- DS not available with NLTAIR2 PIRHN, PIR, PER, PER5, PER7, BL30, BL50, FAO and DMG.
- DS requires (2) separately switched circuits. DS provides 50/50 fixture operation via (2) different sets of leads using (2) drivers. DS only available with packages P8, P9, P10, P11, P12 and P13.
- Reference Motion Sensor Default Settings table on page 4 to see functionality.
- Reference Controls Options table on page 4.
- HS not available with T3LG, T4LG, BLC3, BLC4, LCCO and RCCO distribution. Also available as a separate accessory; see Accessories information.
- CCE option not available with option BS and EGSR. Contact Technical Support for availability.
- Option HA not available with performance packages P4, P5, P7, P8, P9 and P13.
- Requires luminaire to be specified with PER, PER5 or PER7 option. See Controls Table on page 4.
- Single fuse (SF) requires 120V, 277V, or 347V. Double fuse (DF) requires 208V, 240V or 480V. XVOLT not available with fusing (SF or DF).

Shield Accessories




External Glare Shield (EGSR)

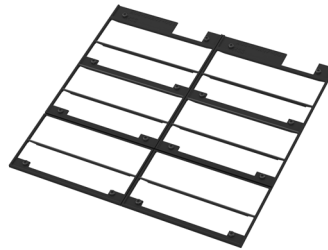

House Side Shield (HS)

Drilling

HANDHOLE ORIENTATION

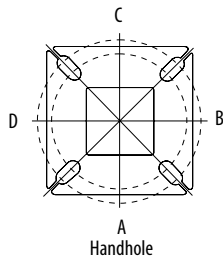


Handhole

Template #8

Top of Pole

1.75" for aluminum poles
2.75" for other pole types

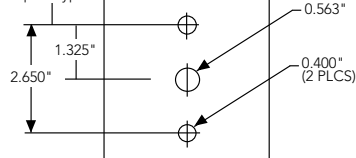

Tenon Mounting Slipfitter

Tenon O.D.	Mounting	Single Unit	2 @ 180	2 @ 90	3 @ 90	3 @ 120	4 @ 90
2-3/8"	RPA	AS3-5 190	AS3-5 280	AS3-5 290	AS3-5 390	AS3-5 320	AS3-5 490
2-7/8"	RPA	AST25-190	AST25-280	AST25-290	AST25-390	AST25-320	AST25-490
4"	RPA	AST35-190	AST35-280	AST35-290	AST35-390	AST35-320	AST35-490

Mounting Option	Drilling Template	Single	2 @ 180	2 @ 90	3 @ 90	3 @ 120	4 @ 90
Head Location		Side B	Side B & D	Side B & C	Side B, C & D	Round Pole Only	Side A, B, C & D
Drill Nomenclature	#8	DM19AS	DM28AS	DM29AS	DM39AS	DM32AS	DM49AS
Minimum Acceptable Outside Pole Dimension							
SPA	#8	3.5"	3.5"	3.5"	3.5"		3.5"
RPA	#8	3"	3"	3"	3"	3"	3"
SPA5	#5	3"	3"	3"	3"		3"
RPA5	#5	3"	3"	3"	3"	3"	3"
SPA8N	#8	3"	3"	3"	3"		3"

DSX1 Area Luminaire - EPA

*Includes luminaire and integral mounting arm. Other tenons, arms, brackets or other accessories are not included in this EPA data.

Fixture Quantity & Mounting Configuration	Single DM19	2 @ 180 DM28	2 @ 90 DM29	3 @ 90 DM39	3 @ 120 DM32	4 @ 90 DM49
Mounting Type						
DSX1 with SPA	0.69	1.38	1.23	1.54	---	1.58
DSX1 with SPA5, SPA8N	0.70	1.40	1.30	1.66	---	1.68
DSX1 with RPA, RPA5	0.70	1.40	1.30	1.66	1.60	1.68
DSX1 with MA	0.83	1.66	1.50	2.09	2.09	2.09

Photometric Diagrams

To see complete photometric reports or download .ies files for this product, visit Lithonia Lighting's [homepage](https://www.lithonia.com).

Isofootcandle plots for the DSX1 LED P9 40K 70CRI. Distances are in units of mounting height (25').

LEGEND

